
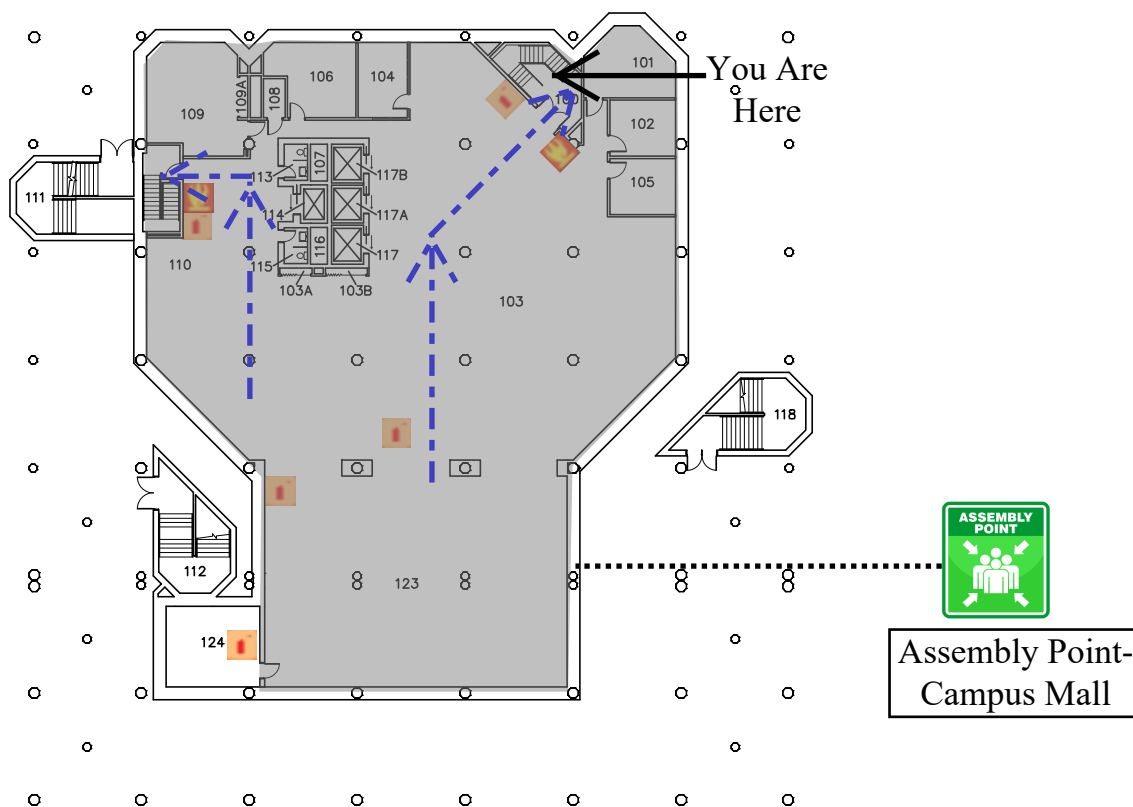


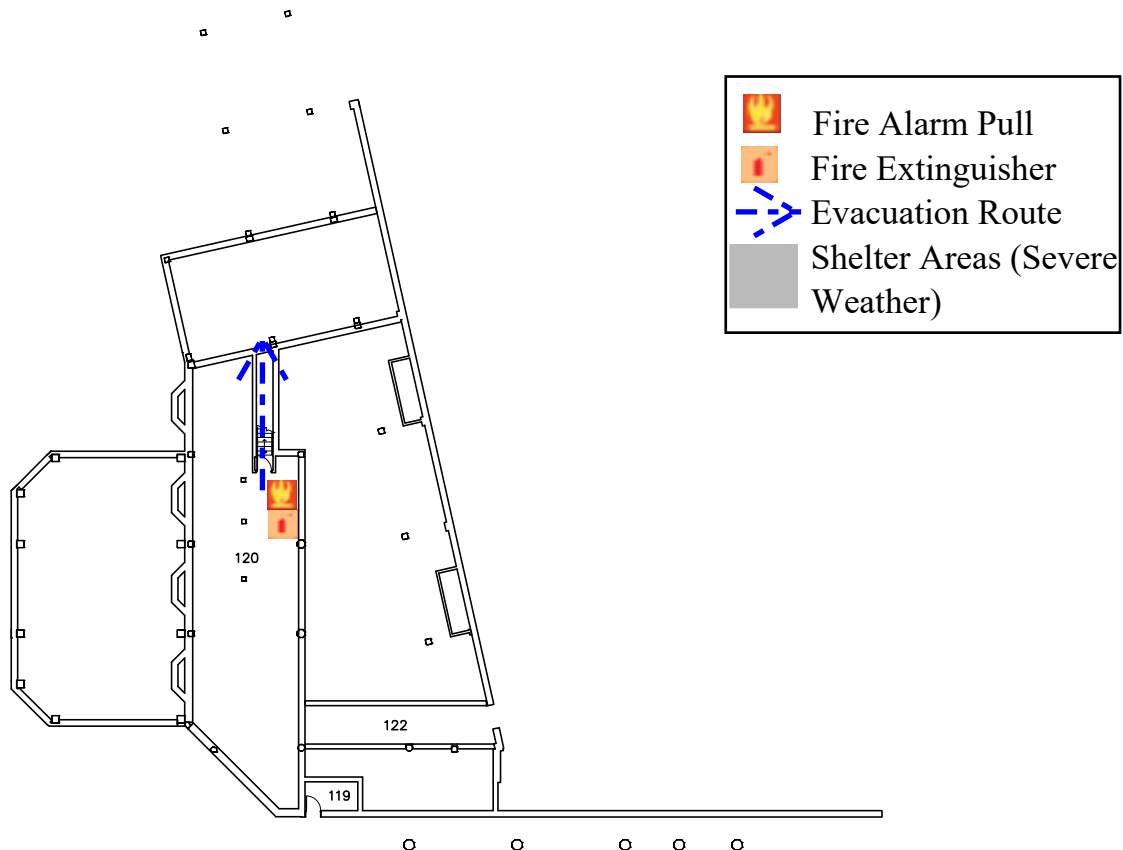

University of Wisconsin-Eau Claire Facilities

McIntyre Library Basement Floor Plan



DATE:

Jan 2022

DWG NO:

1



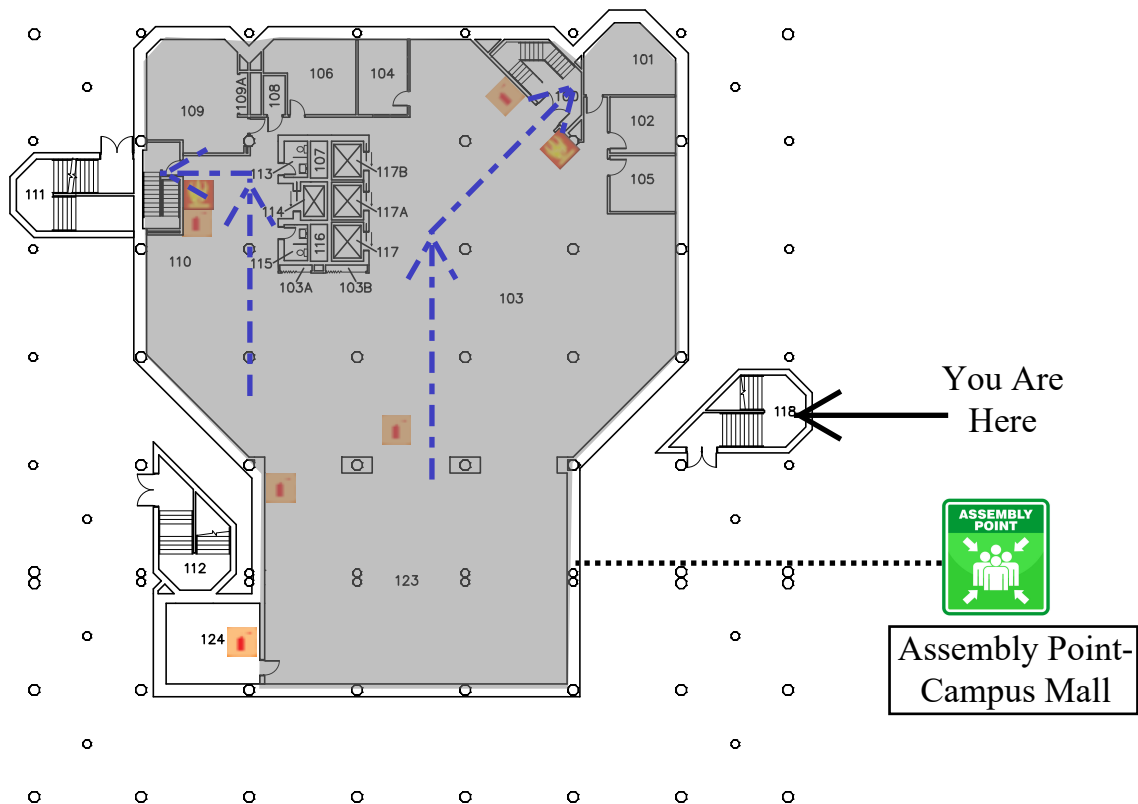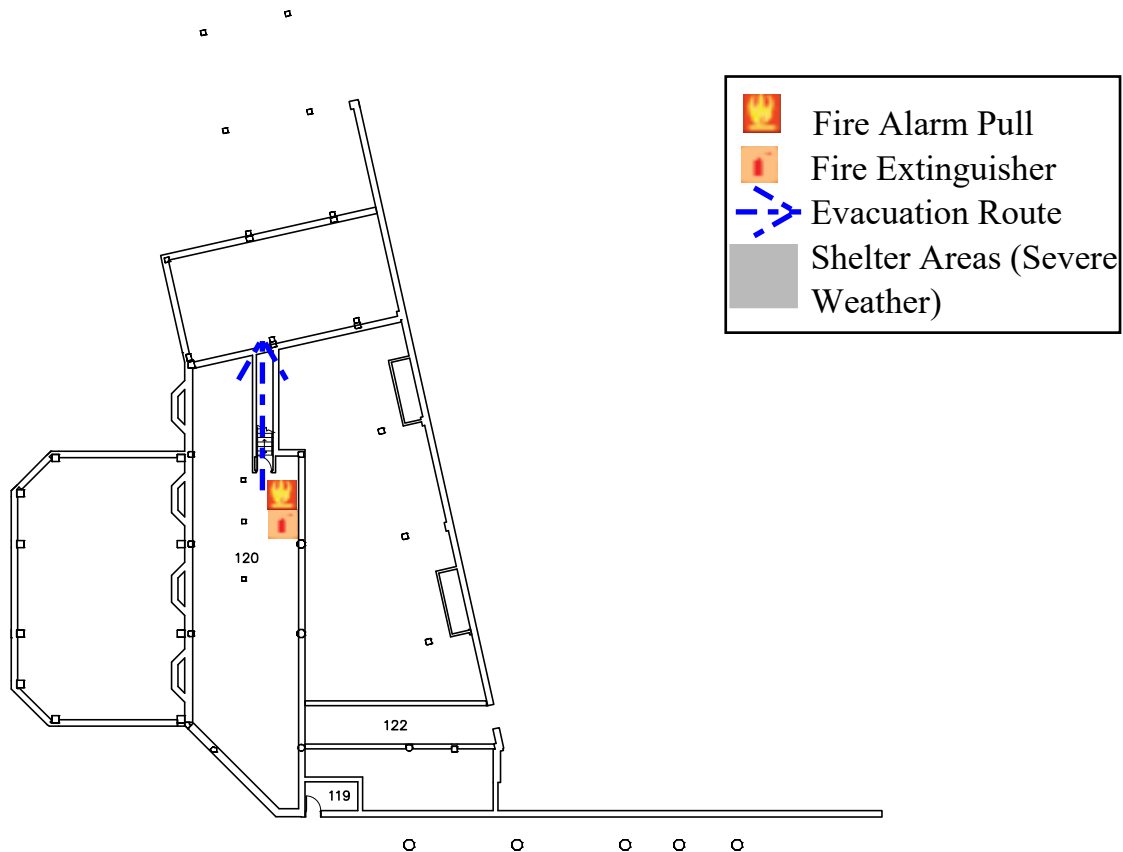

University of Wisconsin-Eau Claire

Facilities

McIntyre Library Basement Floor Plan



DATE:

Jan 2022

DWG NO:

2



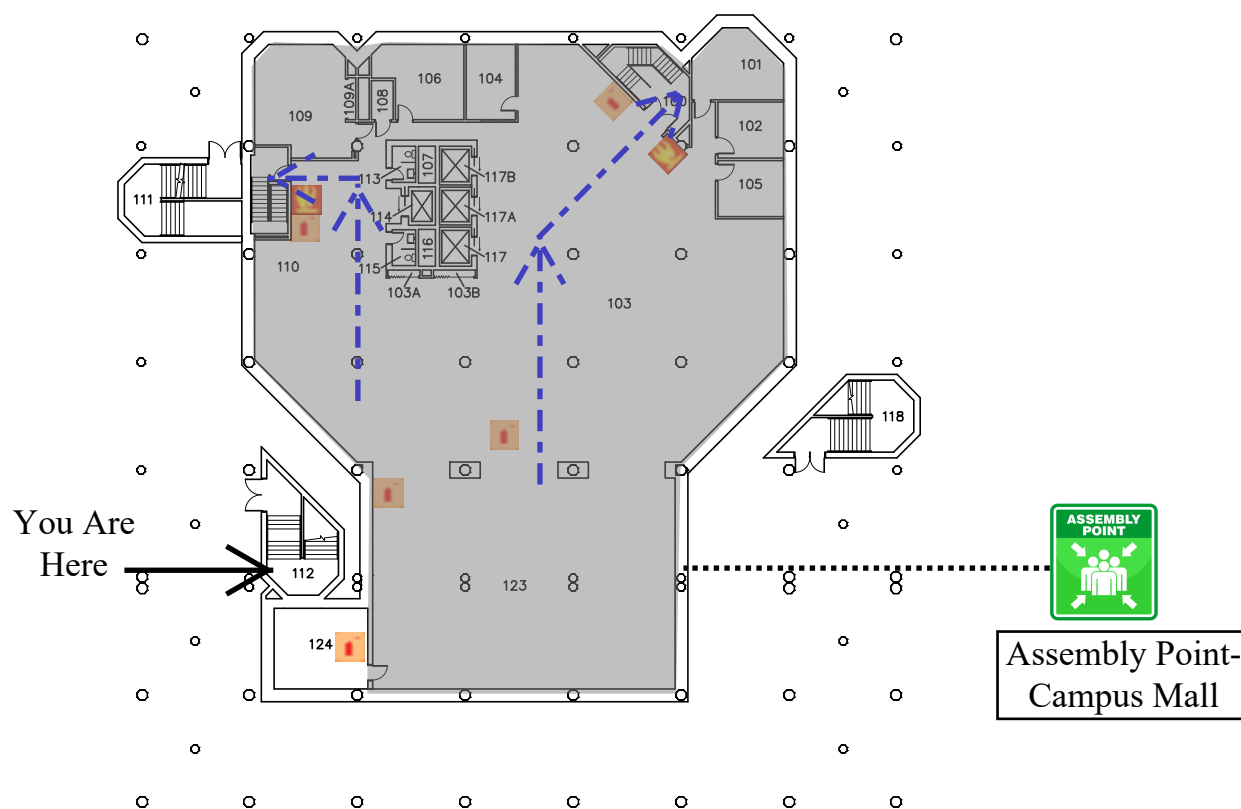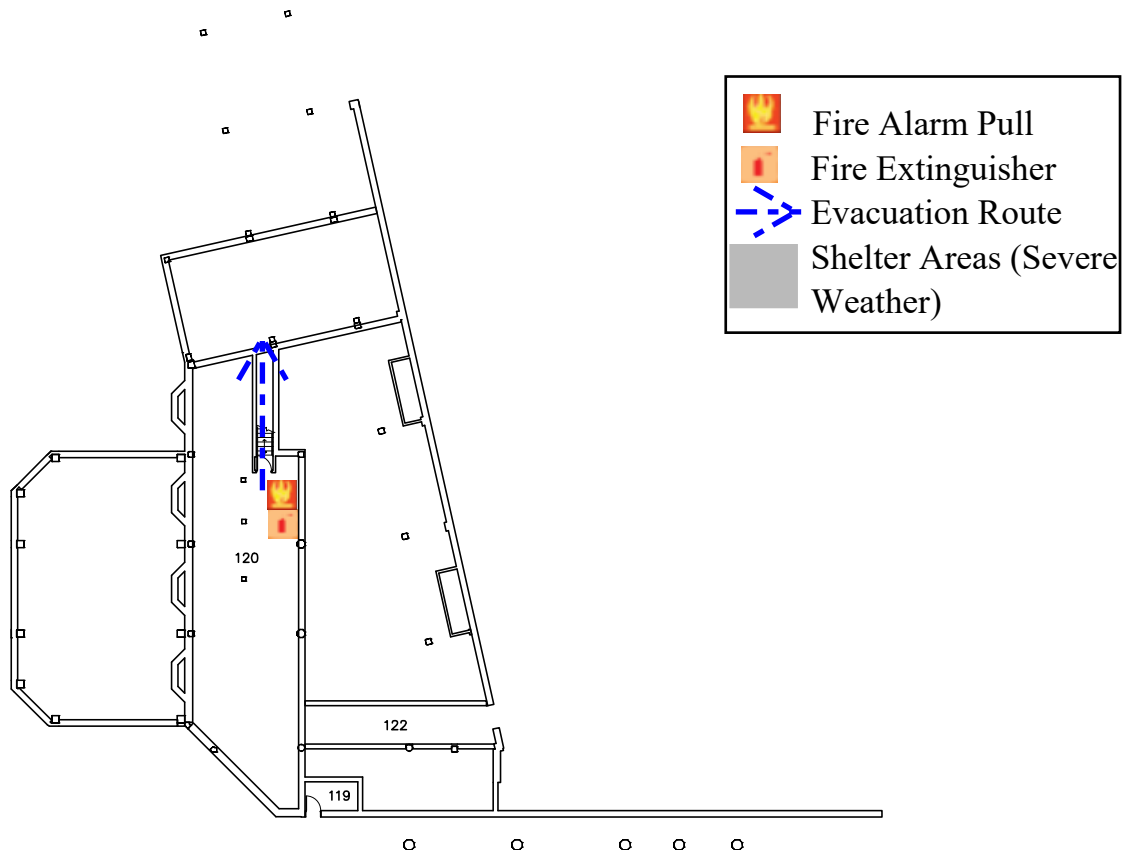

University of Wisconsin-Eau Claire

Facilities

McIntyre Library Basement Floor Plan



DATE:

Jan 2022

DWG NO:

3



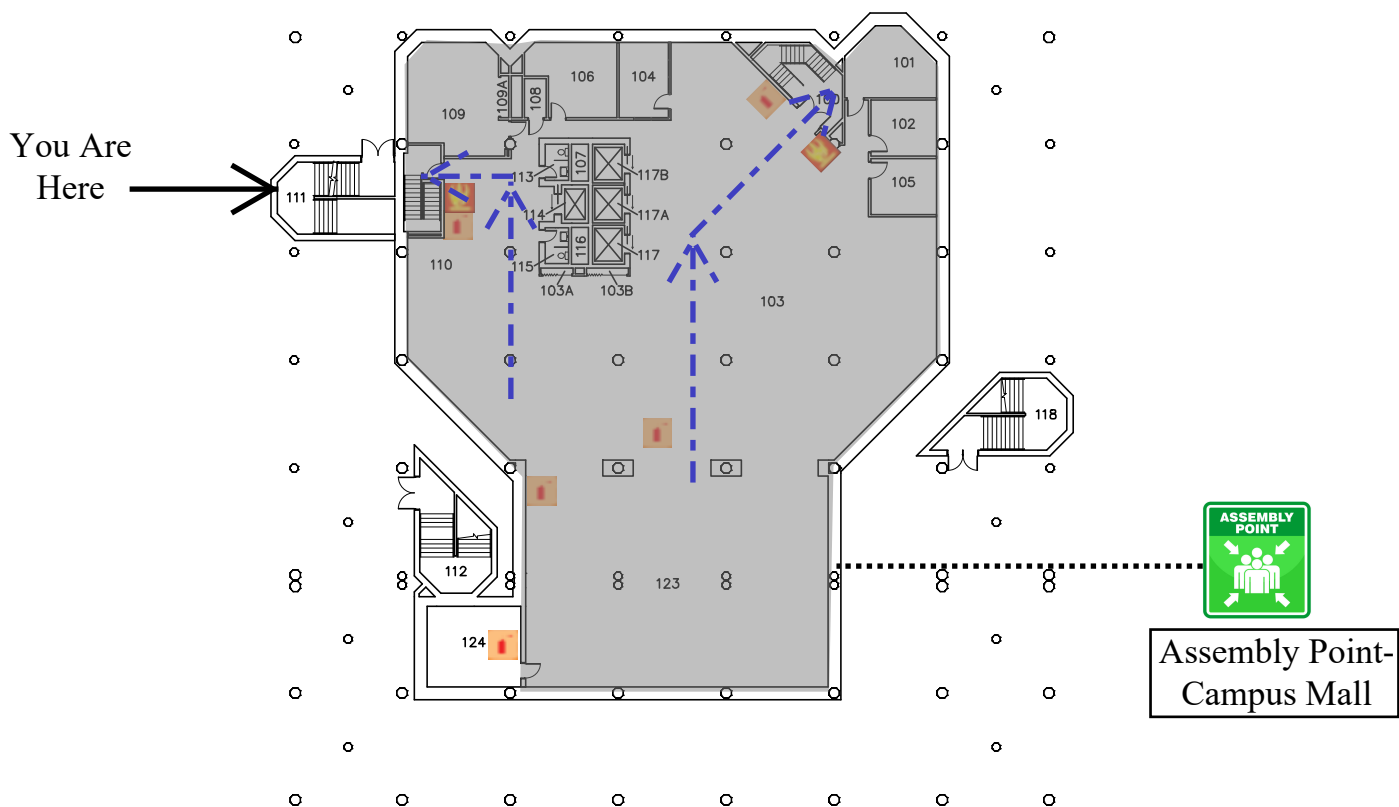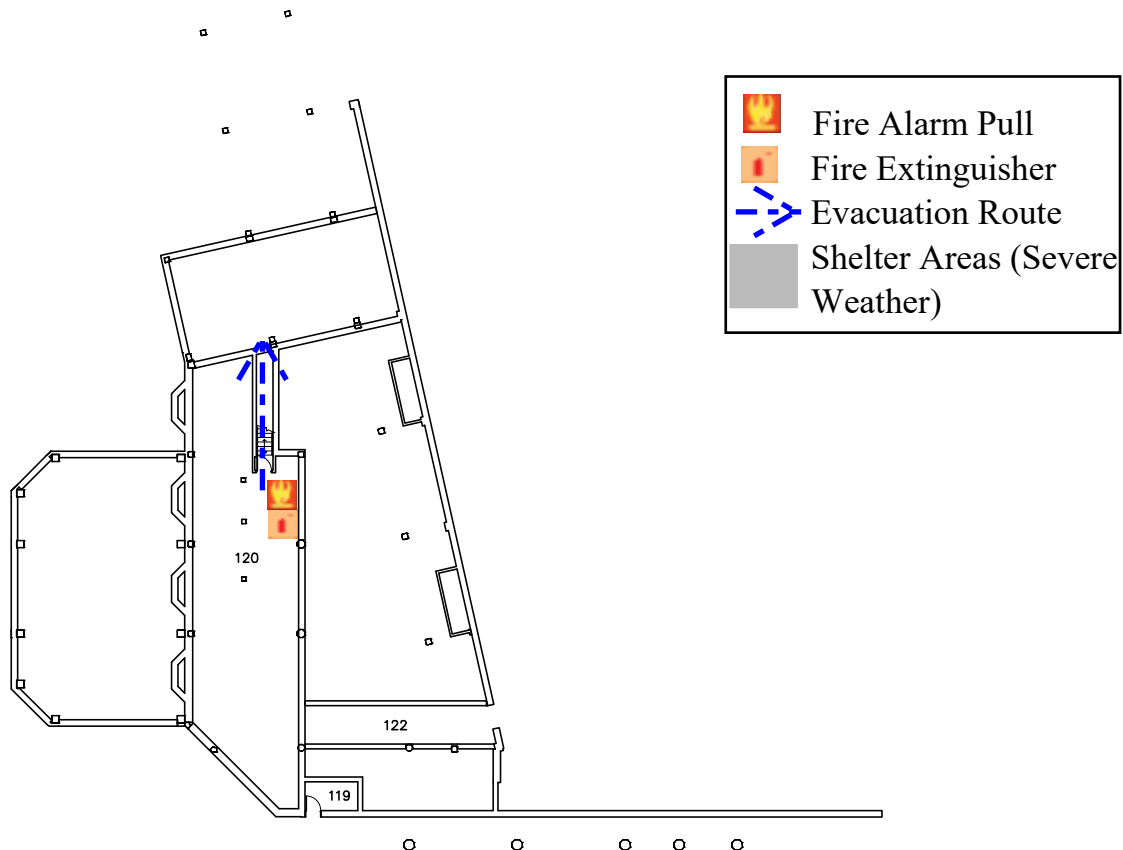

University of Wisconsin-Eau Claire

Facilities

McIntyre Library Basement Floor Plan


DATE:

Jan 2022

DWG NO:


4



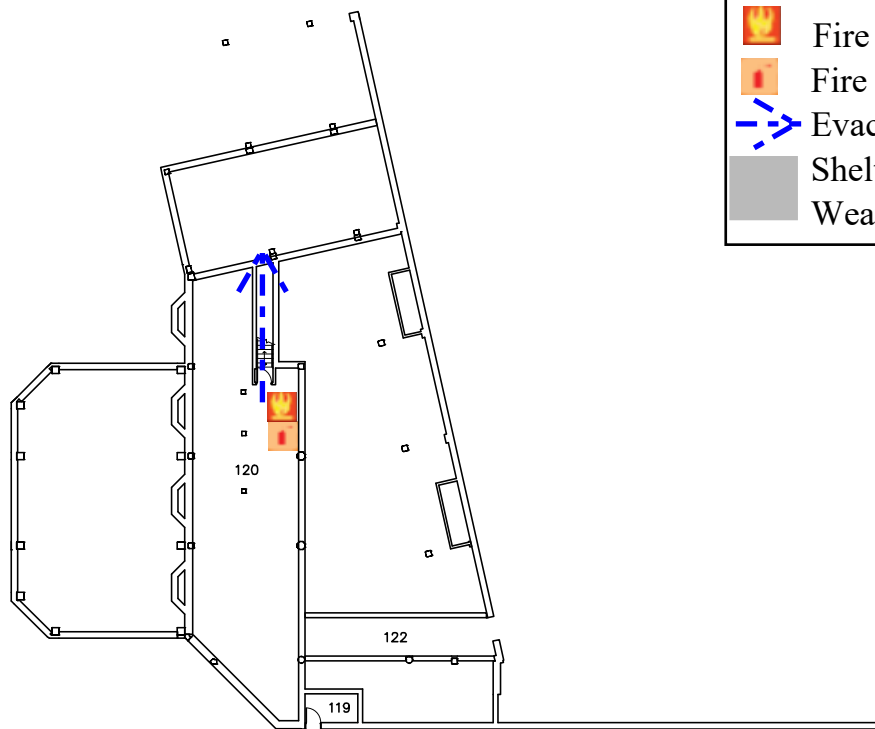

-  Fire Alarm Pull
-  Fire Extinguisher
-  Evacuation Route
-  Shelter Areas (Severe Weather)

You Are
Here

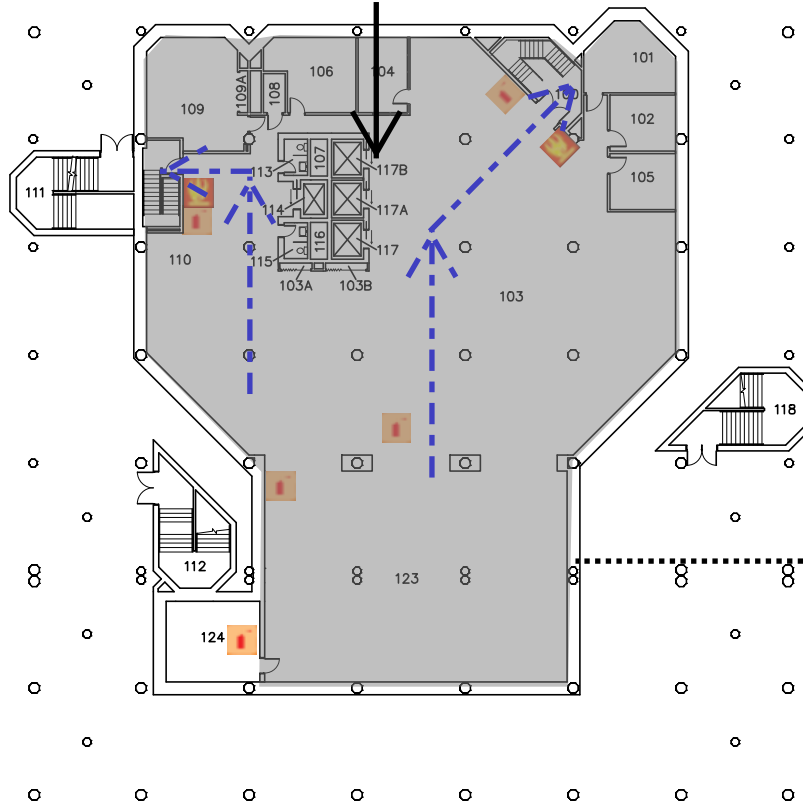

Assembly Point-
Campus Mall



University of Wisconsin-Eau Claire

Facilities

McIntyre Library Basement Floor Plan



DATE:

Jan 2022

DWG NO:

5



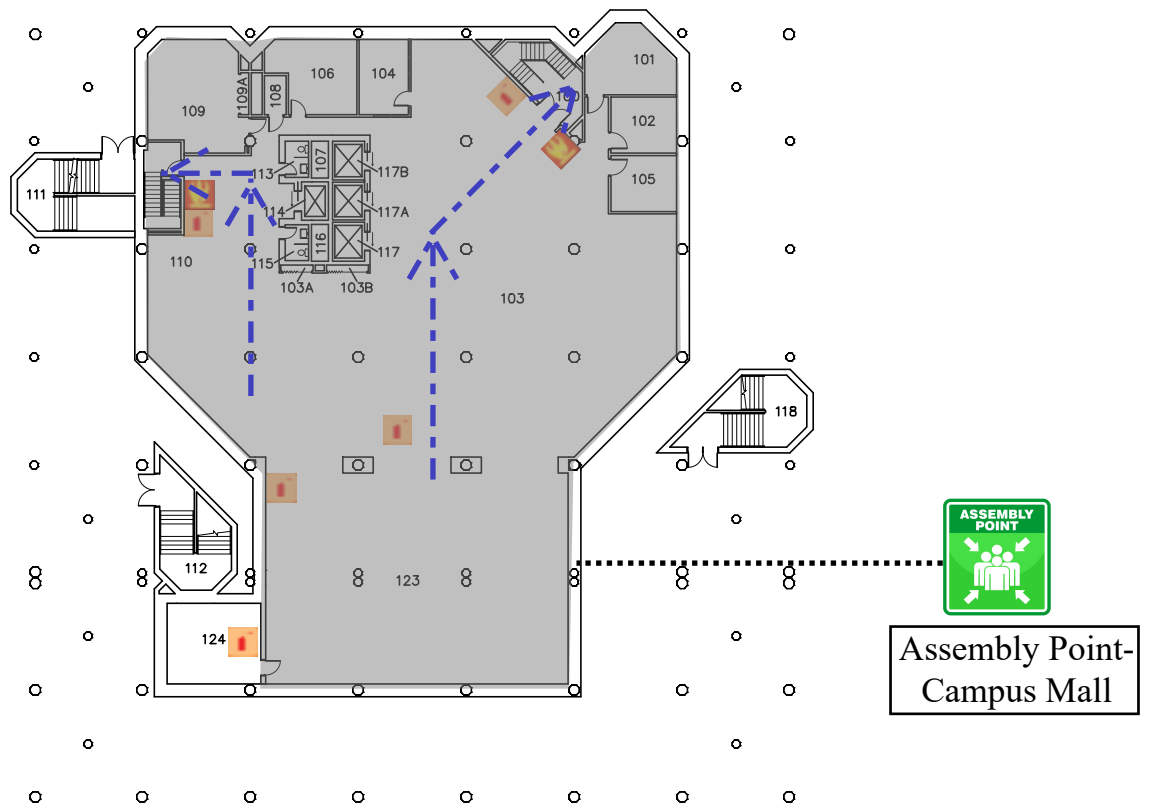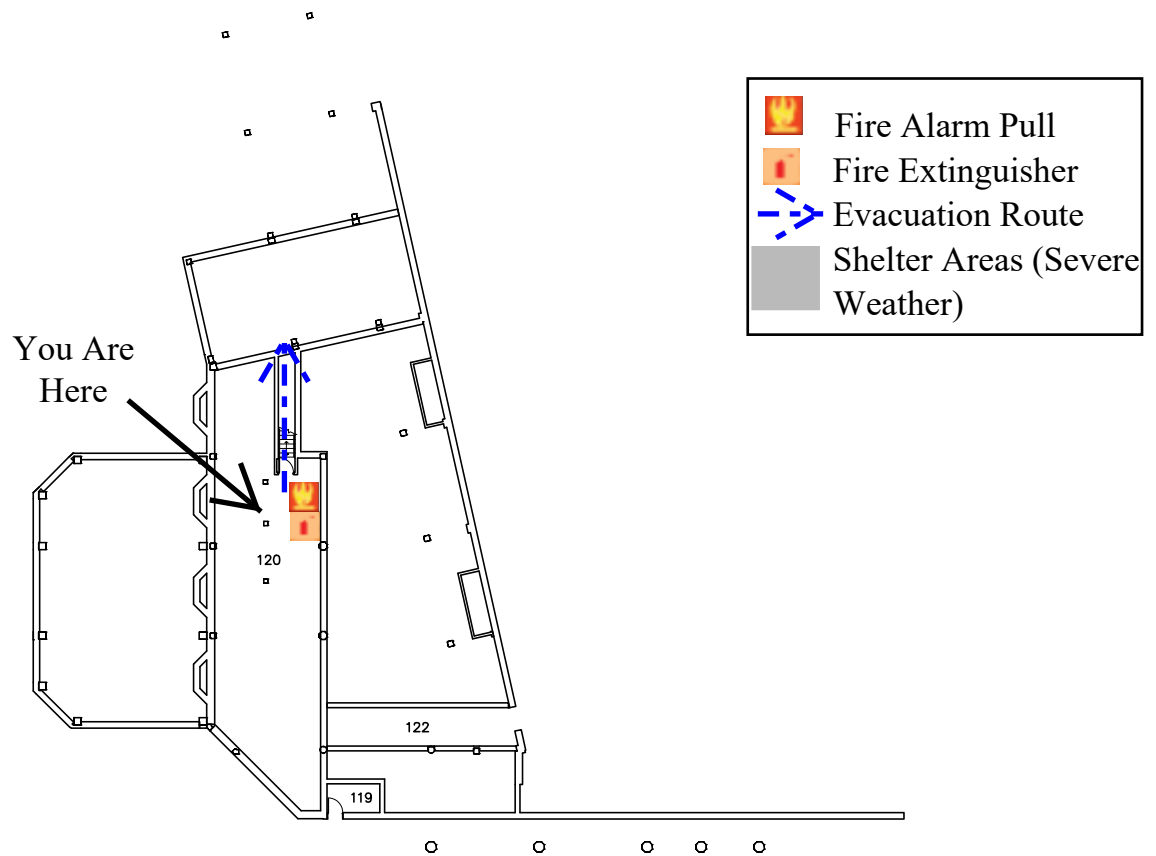

University of Wisconsin-Eau Claire

Facilities

McIntyre Library Basement Floor Plan


DATE:

Jan 2022

DWG NO:

6



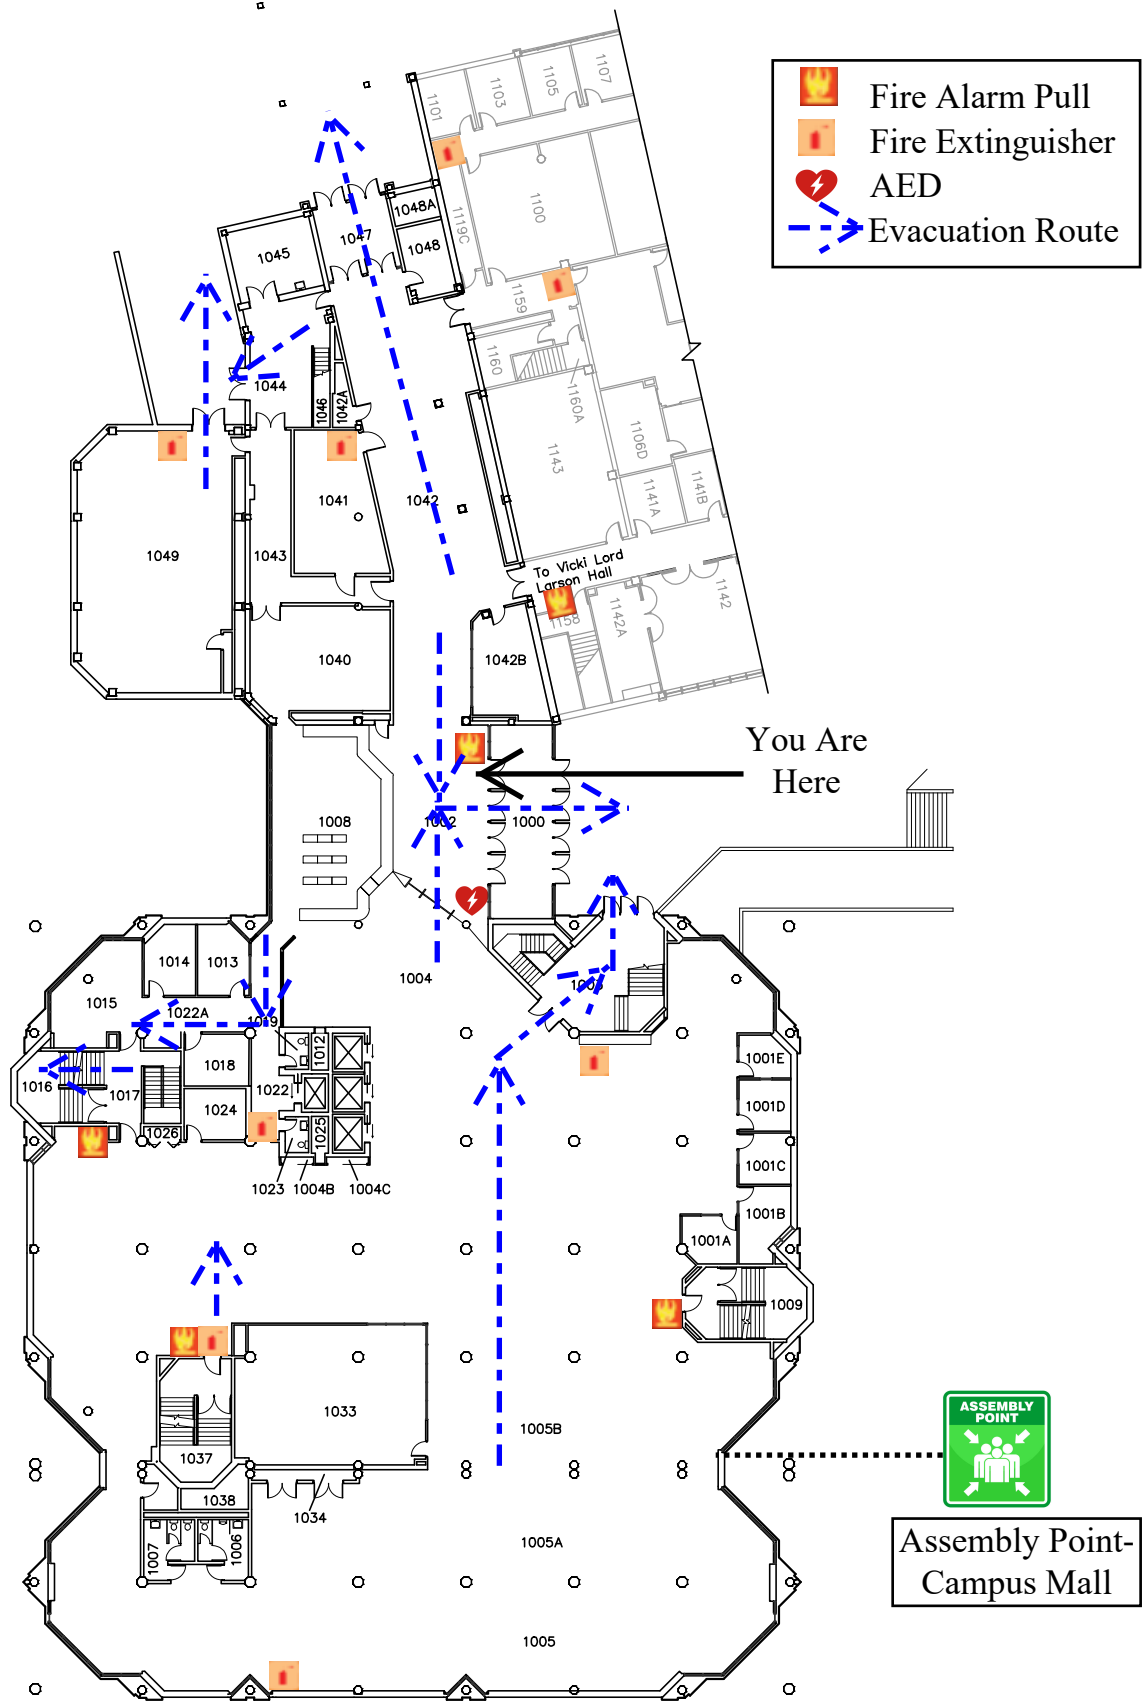

University of Wisconsin-Eau Claire

Facilities

McIntyre Library First Floor Plan


DATE:

Jan 2022

DWG NO:

1



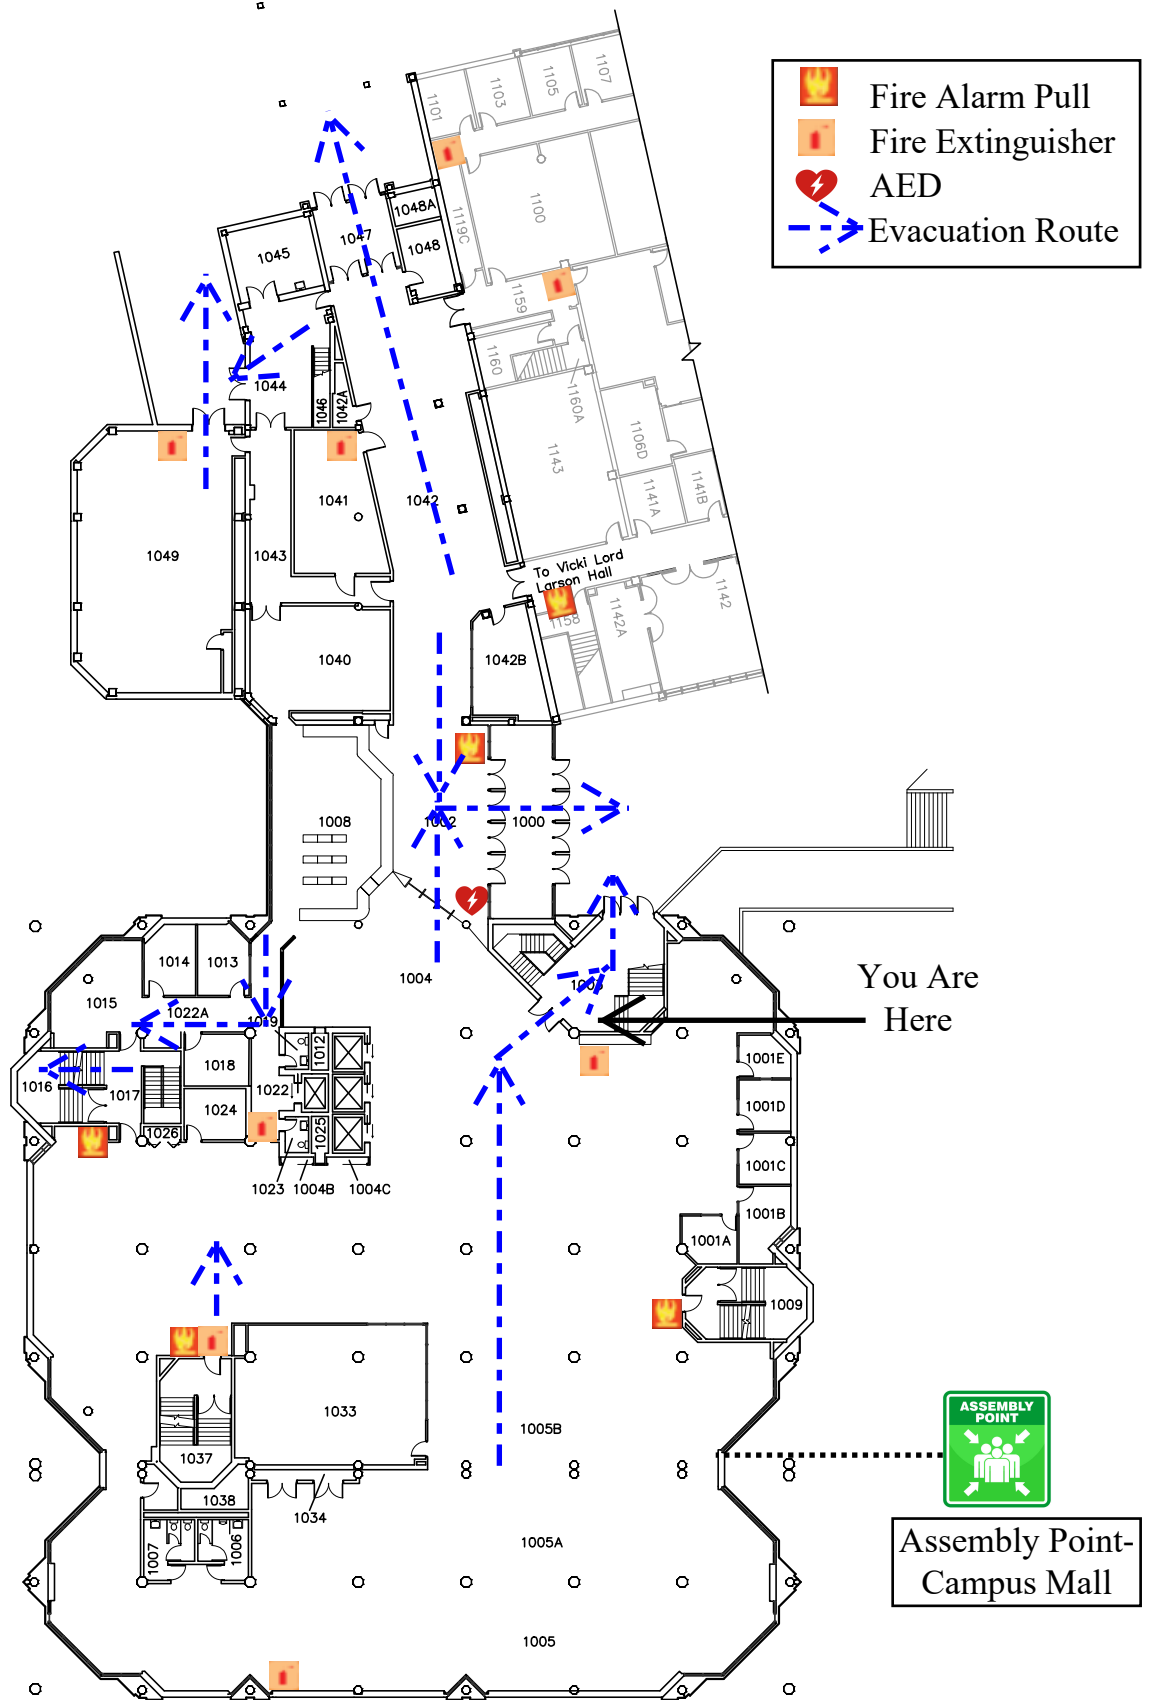

University of Wisconsin-Eau Claire

Facilities

McIntyre Library First Floor Plan


DATE:

Jan 2022

DWG NO:

2



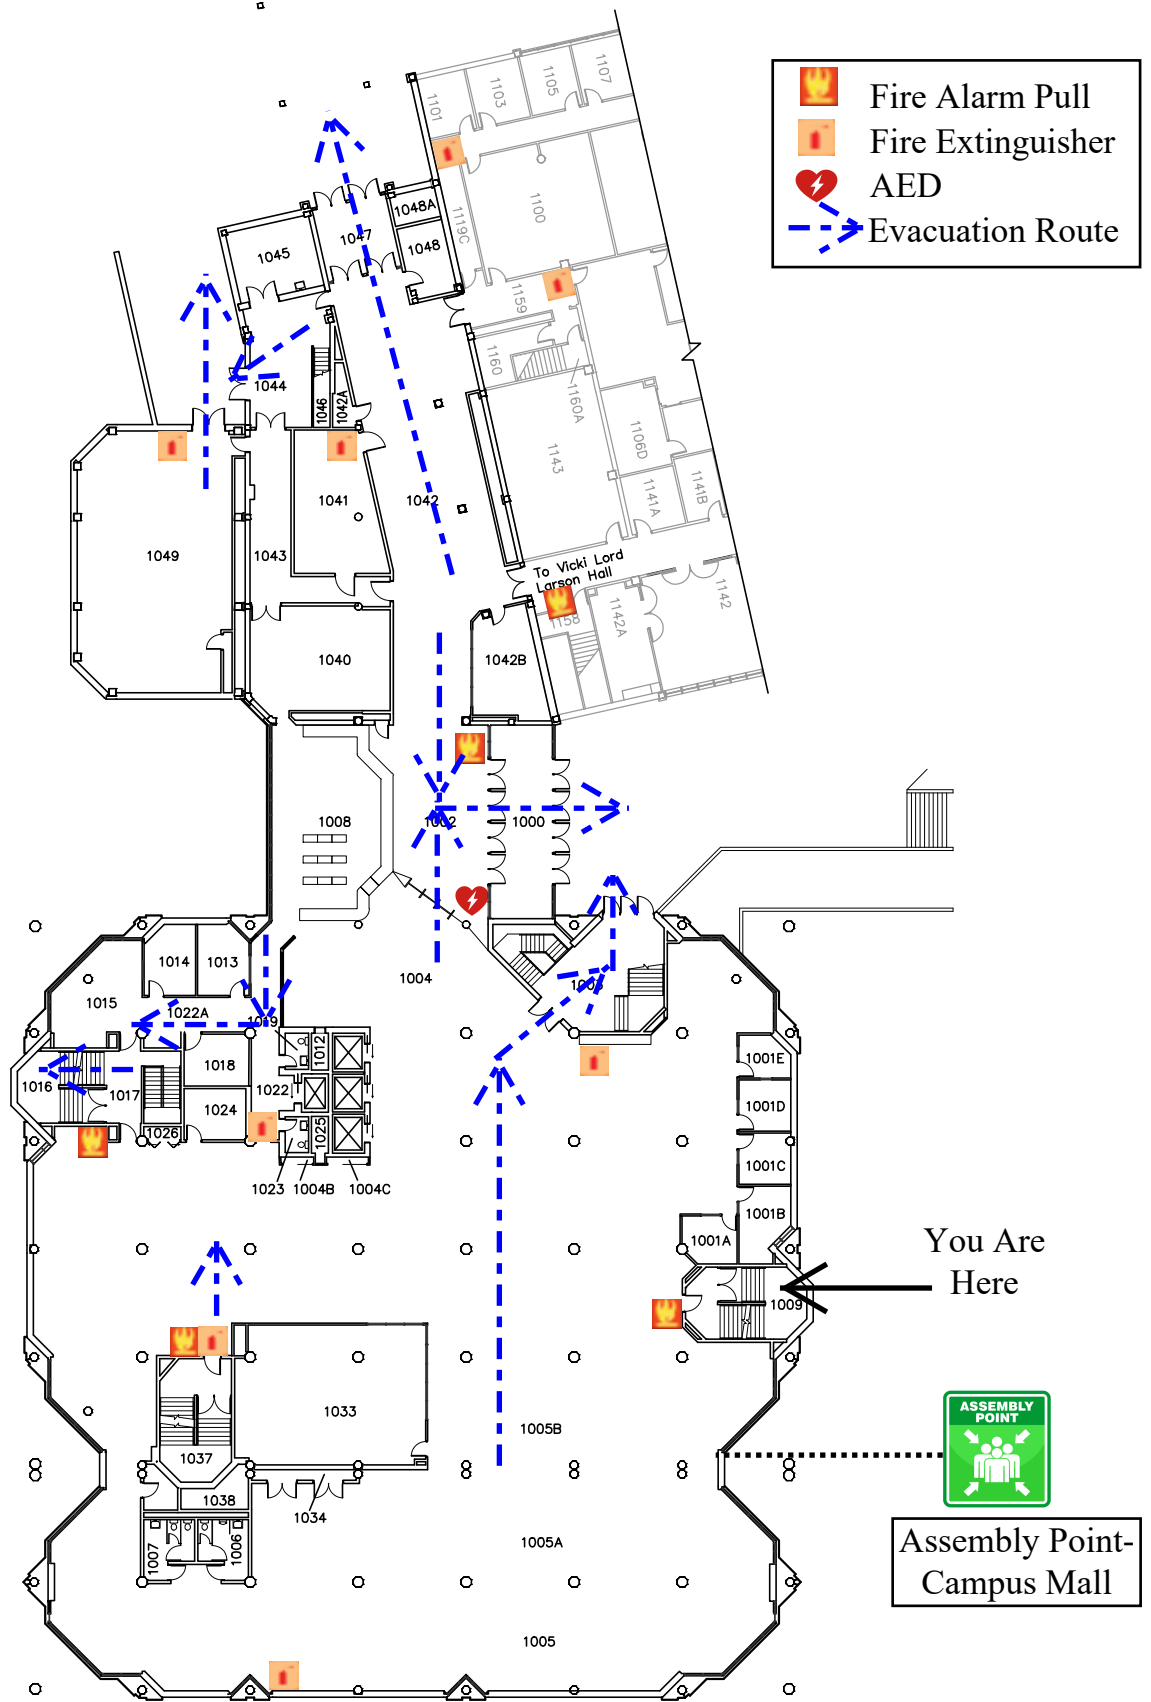

University of Wisconsin-Eau Claire

Facilities

McIntyre Library First Floor Plan


DATE:

Jan 2022

DWG NO:

3



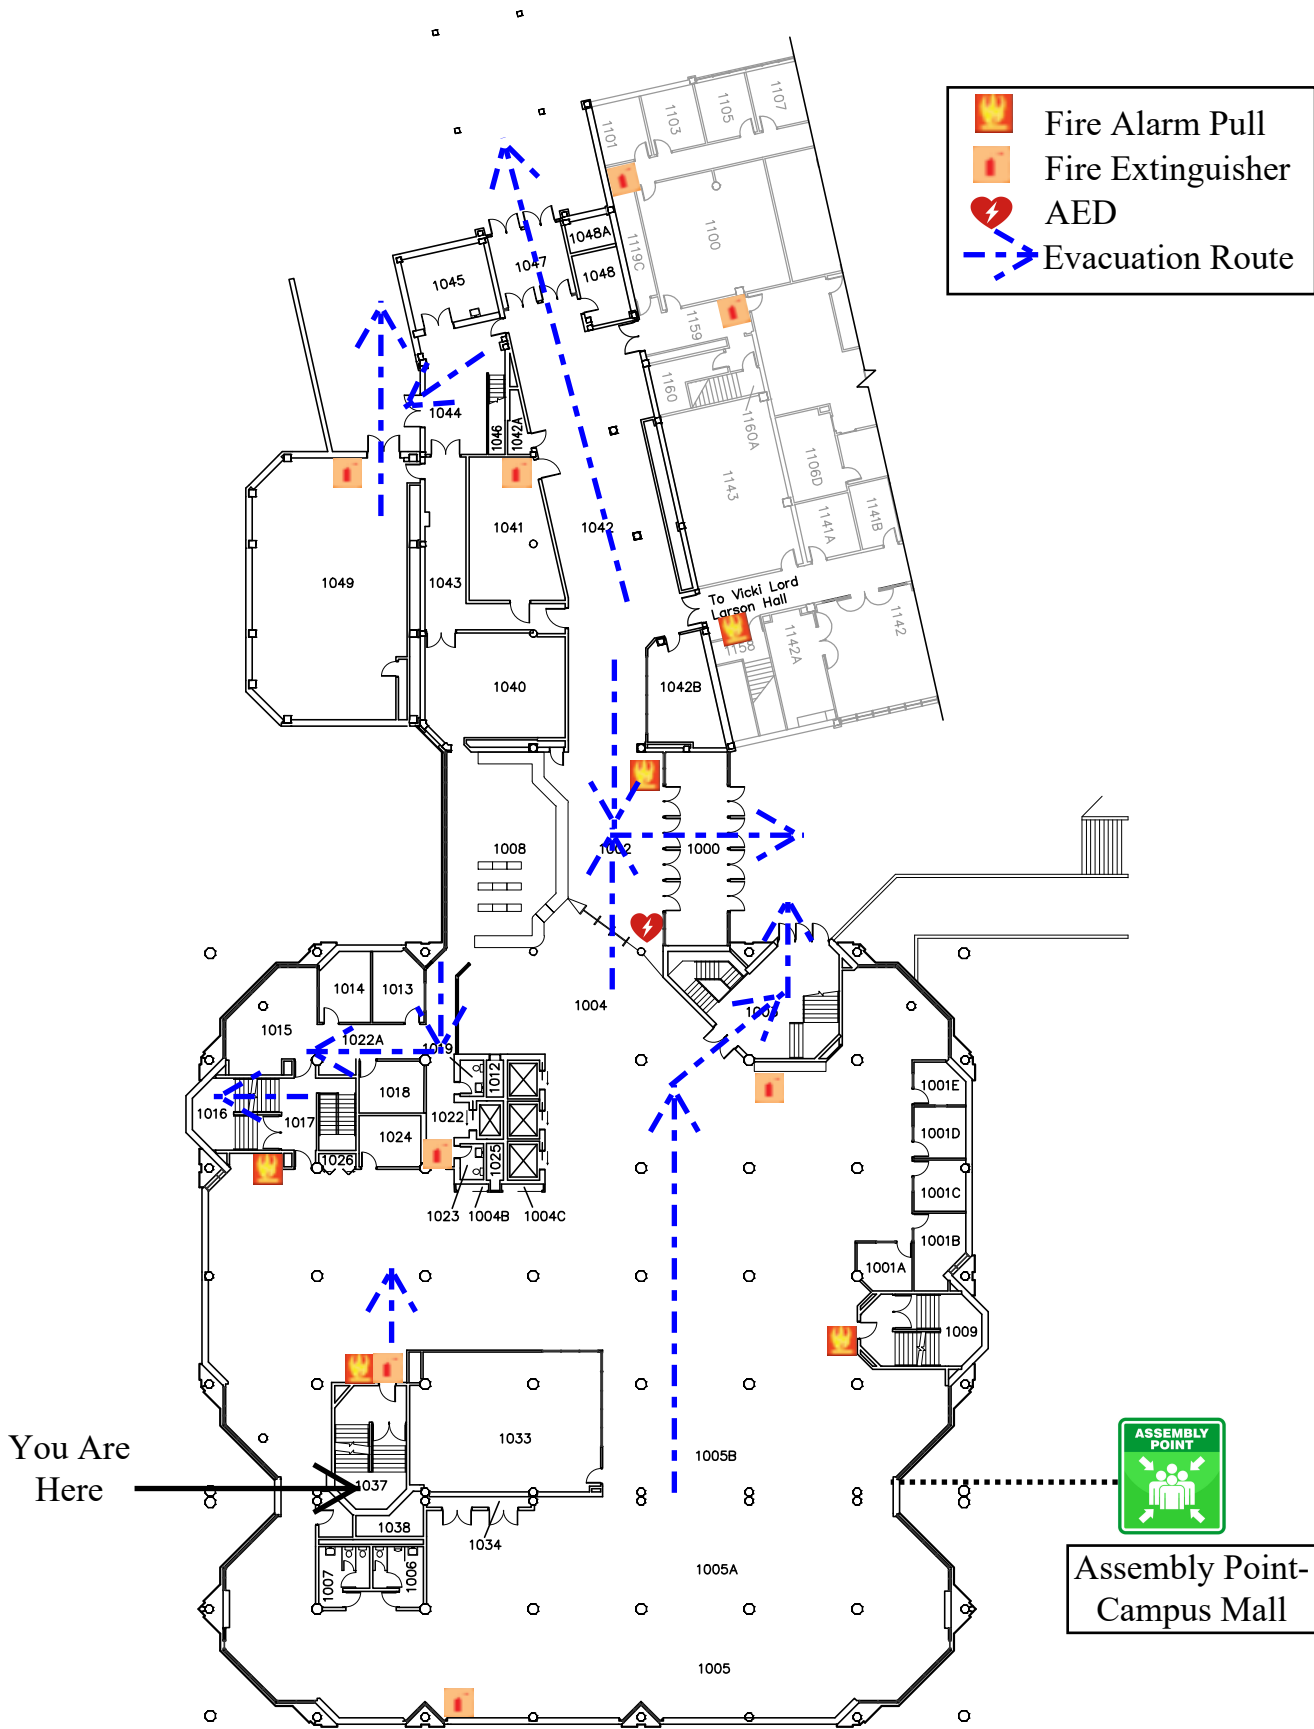

University of Wisconsin-Eau Claire

Facilities

McIntyre Library First Floor Plan

DATE:

Jan 2022


DWG NO:

4



You Are
Here


 Fire Alarm Pull
  Fire Extinguisher
  AED
  Evacuation Route

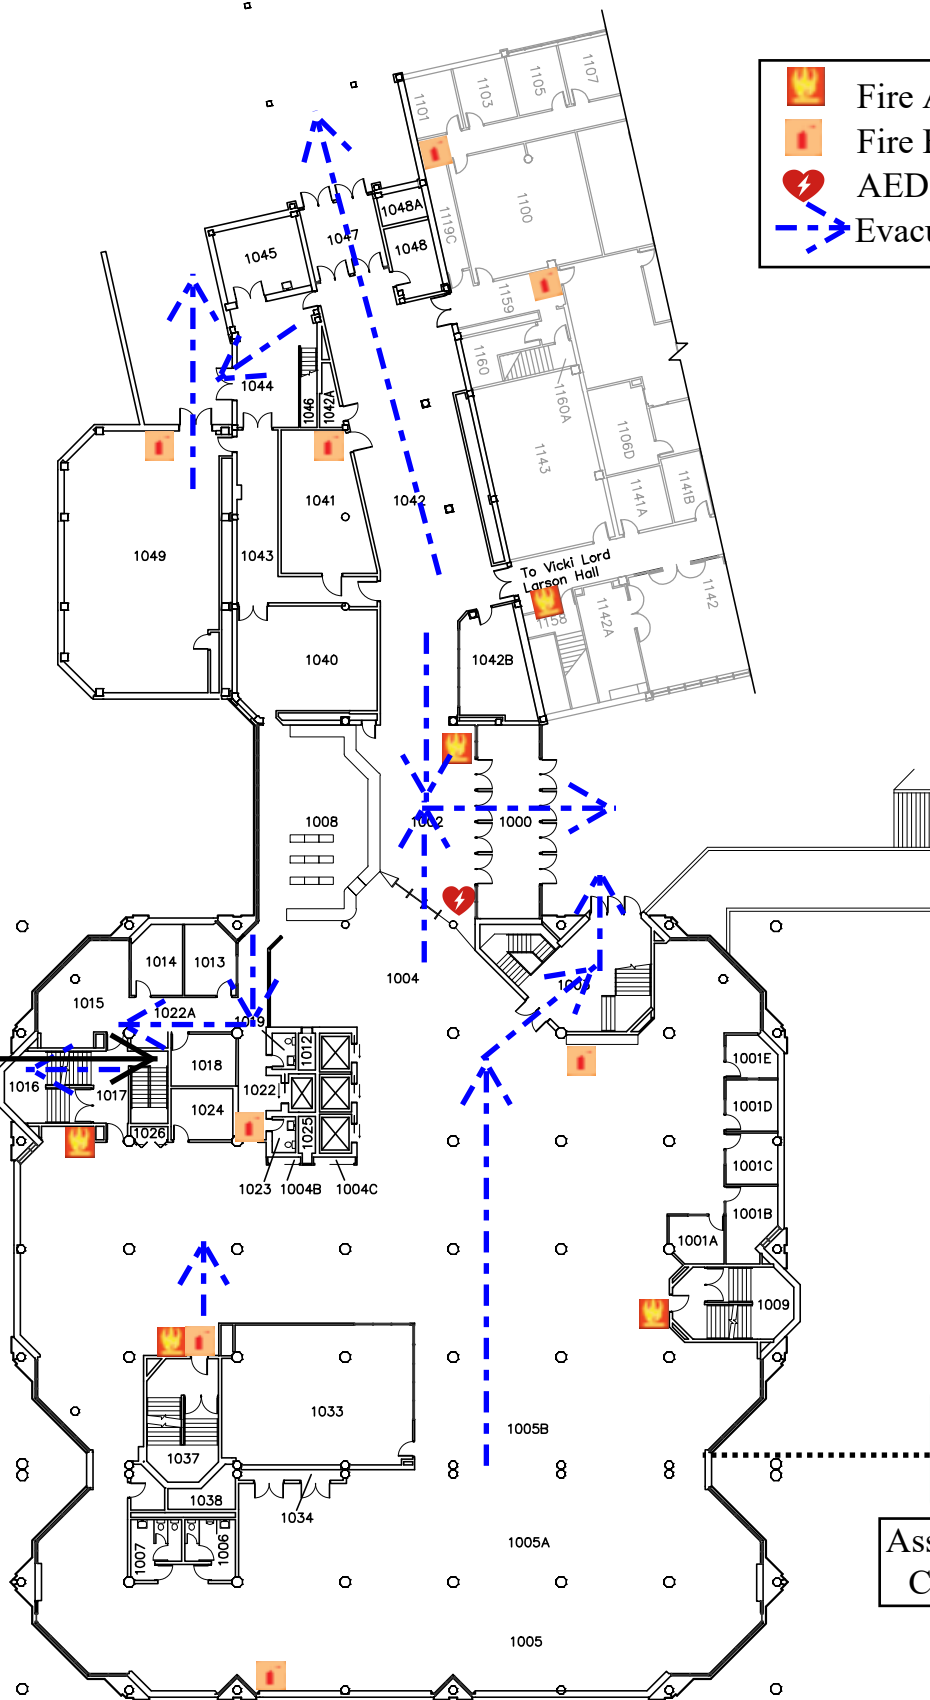



Assembly Point-
Campus Mall



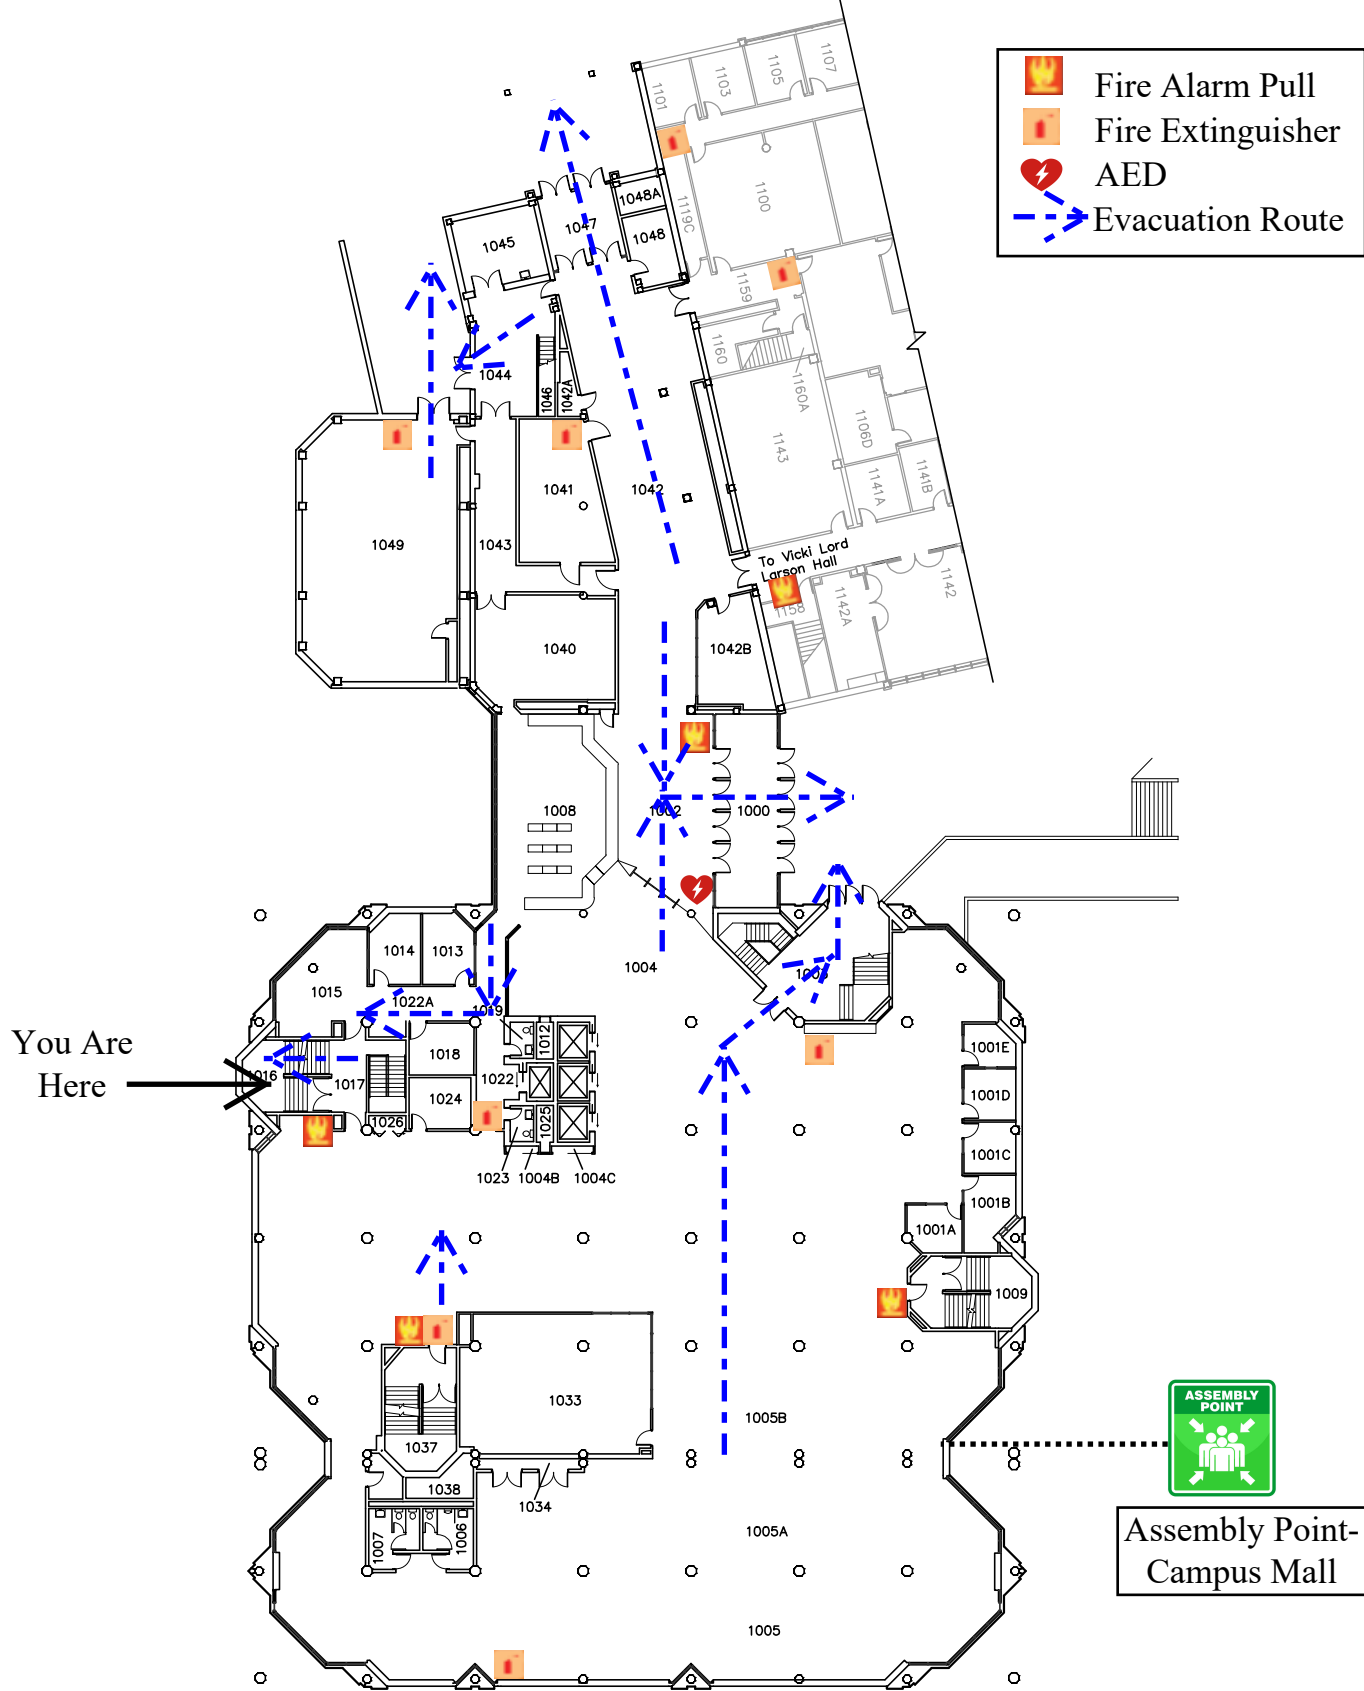

University of Wisconsin-Eau Claire

Facilities

McIntyre Library First Floor Plan


DATE:

Jan 2022

DWG NO:

6



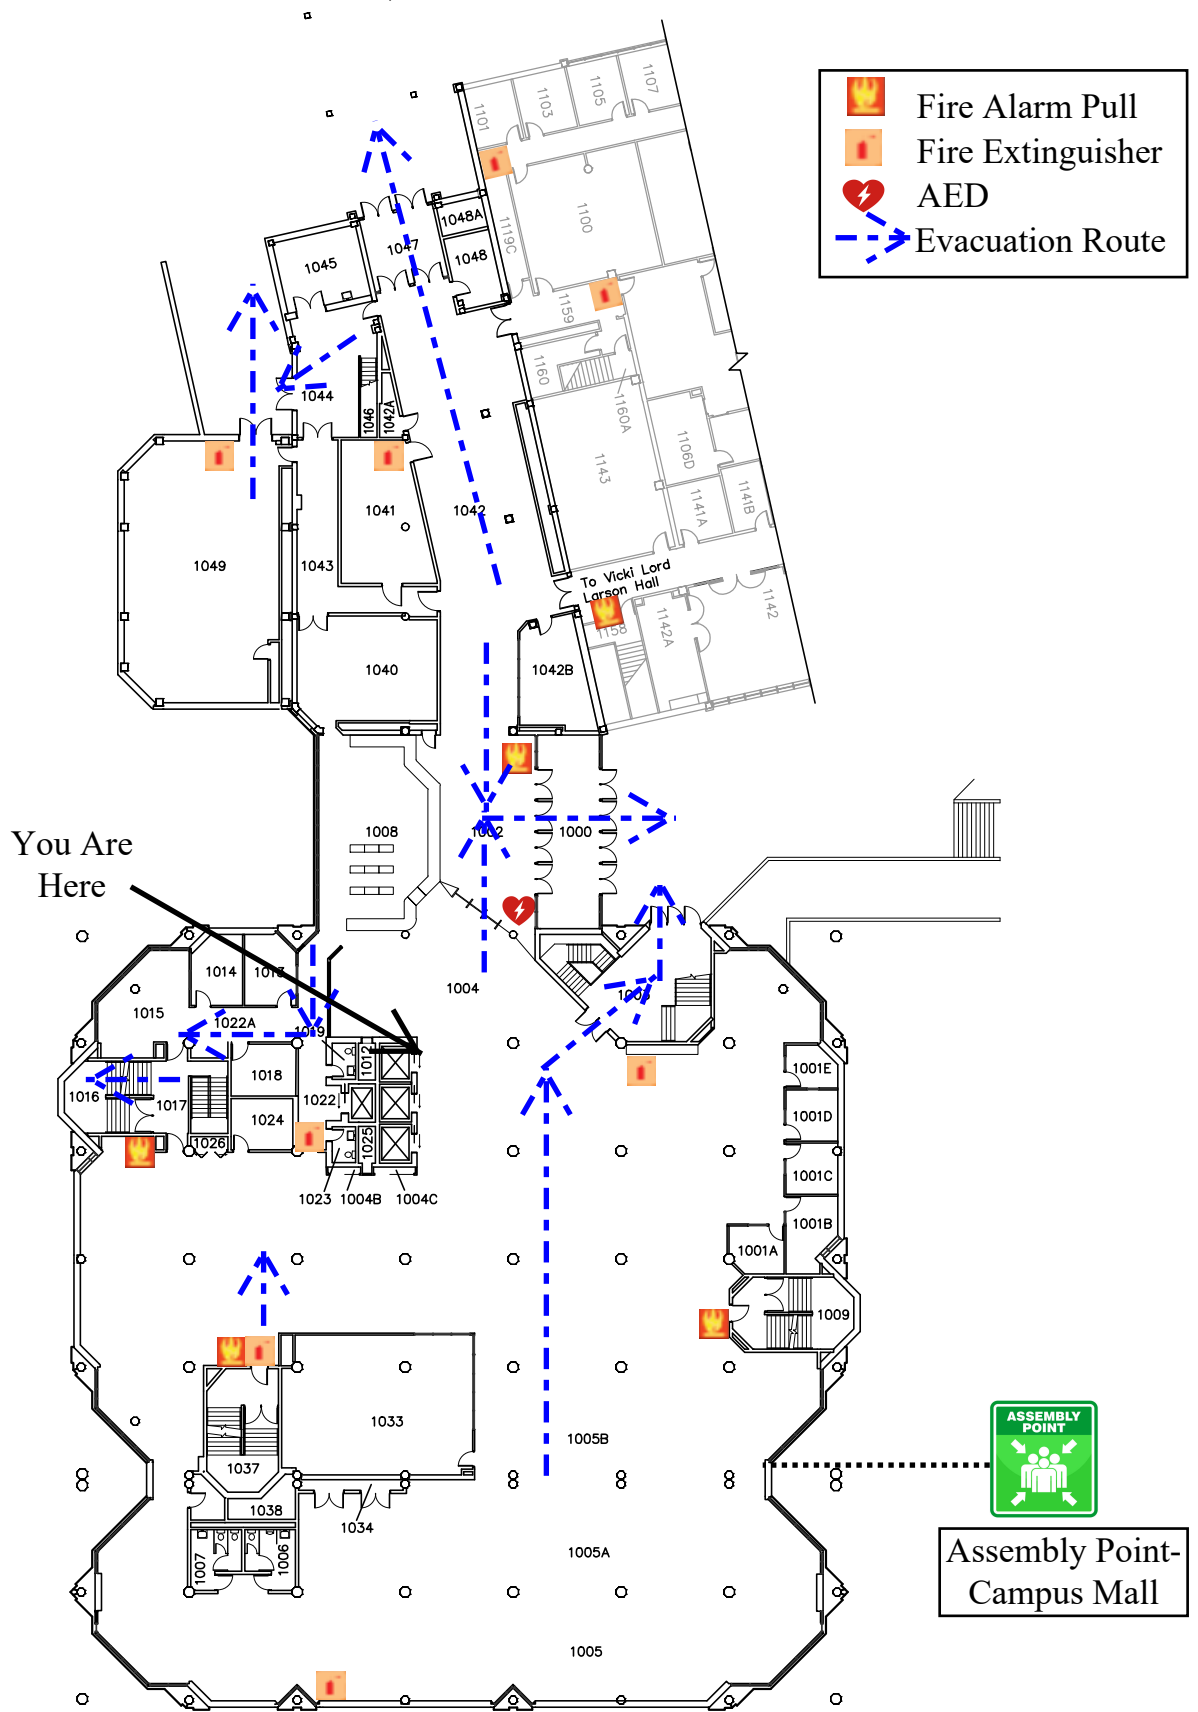

University of Wisconsin-Eau Claire

Facilities

McIntyre Library First Floor Plan


DATE:

Jan 2022

DWG NO:

7



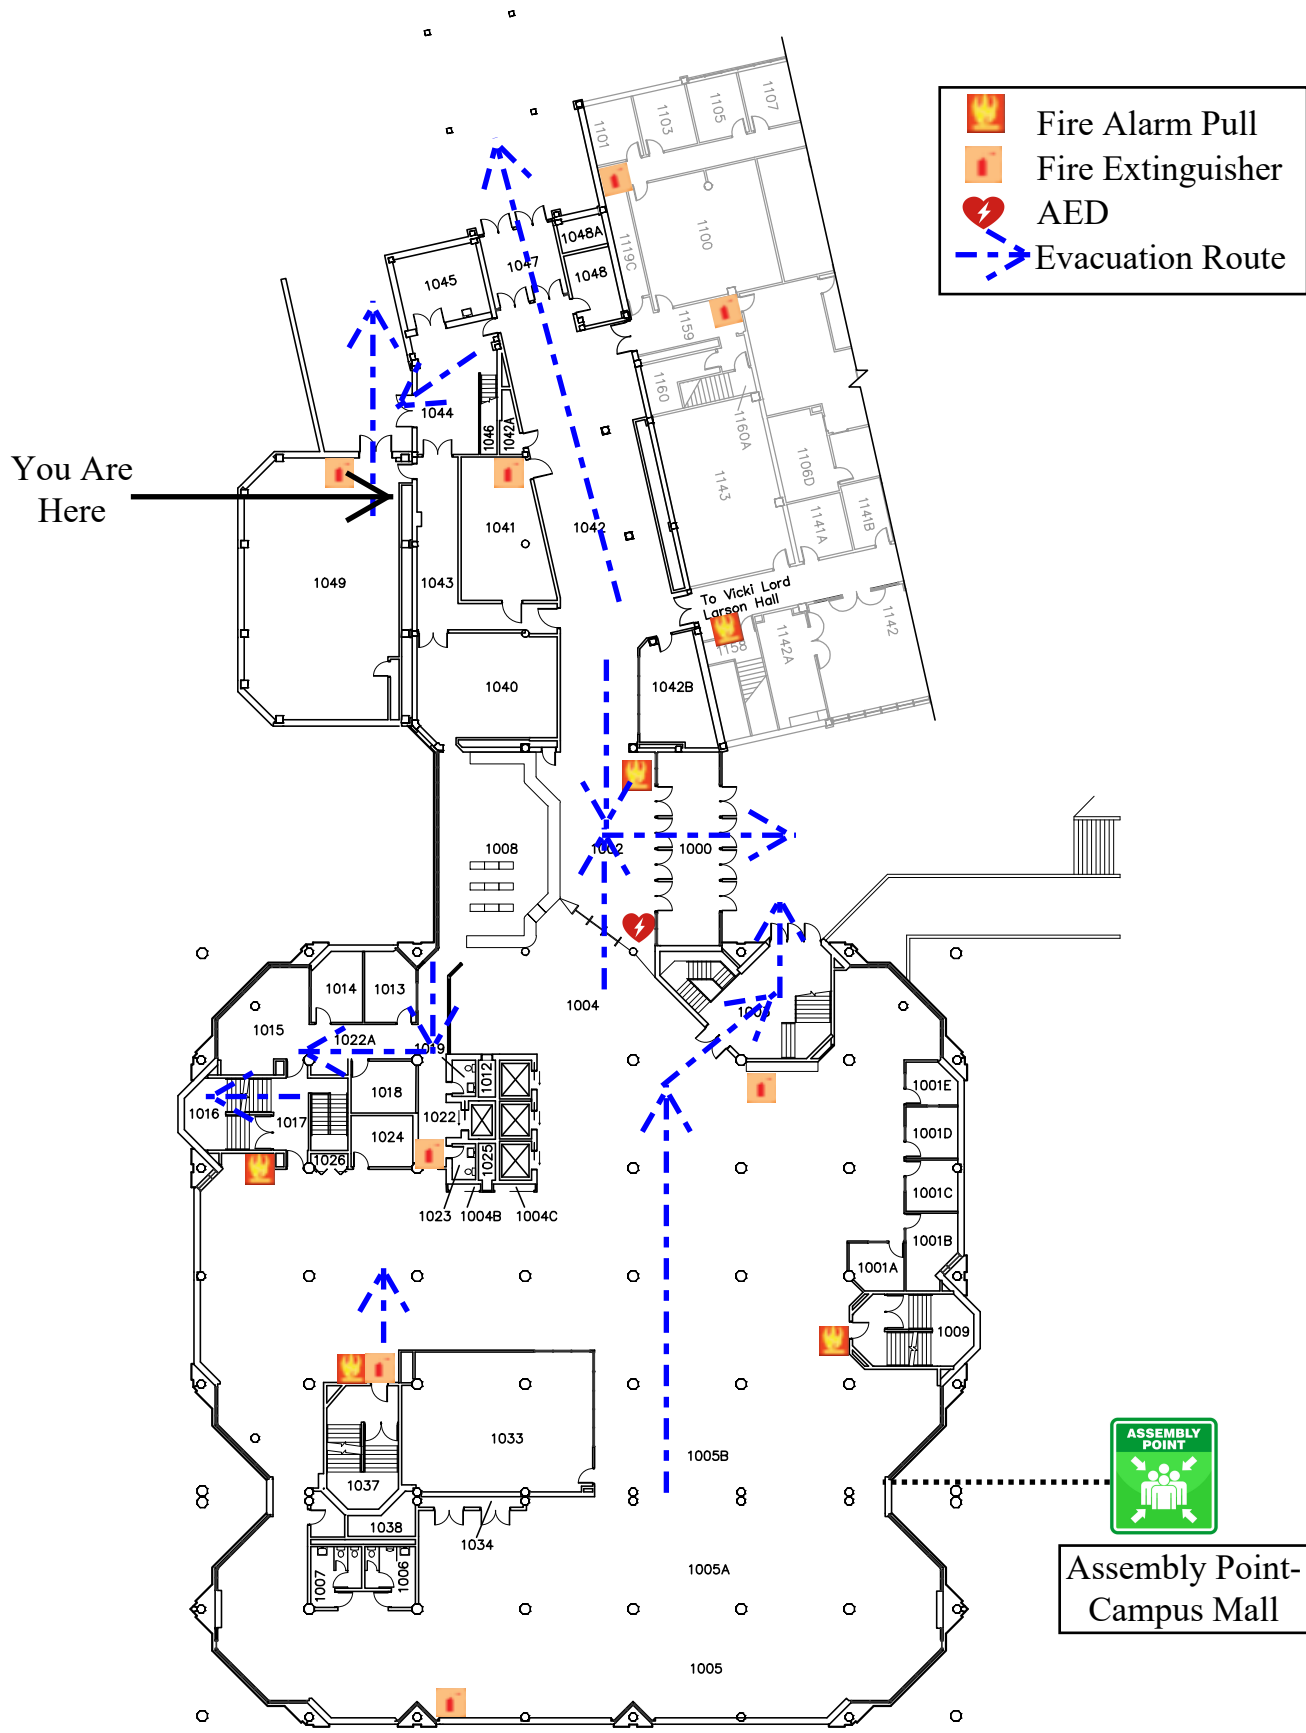

University of Wisconsin-Eau Claire

Facilities

McIntyre Library First Floor Plan


DATE:

Jan 2022

DWG NO:

8



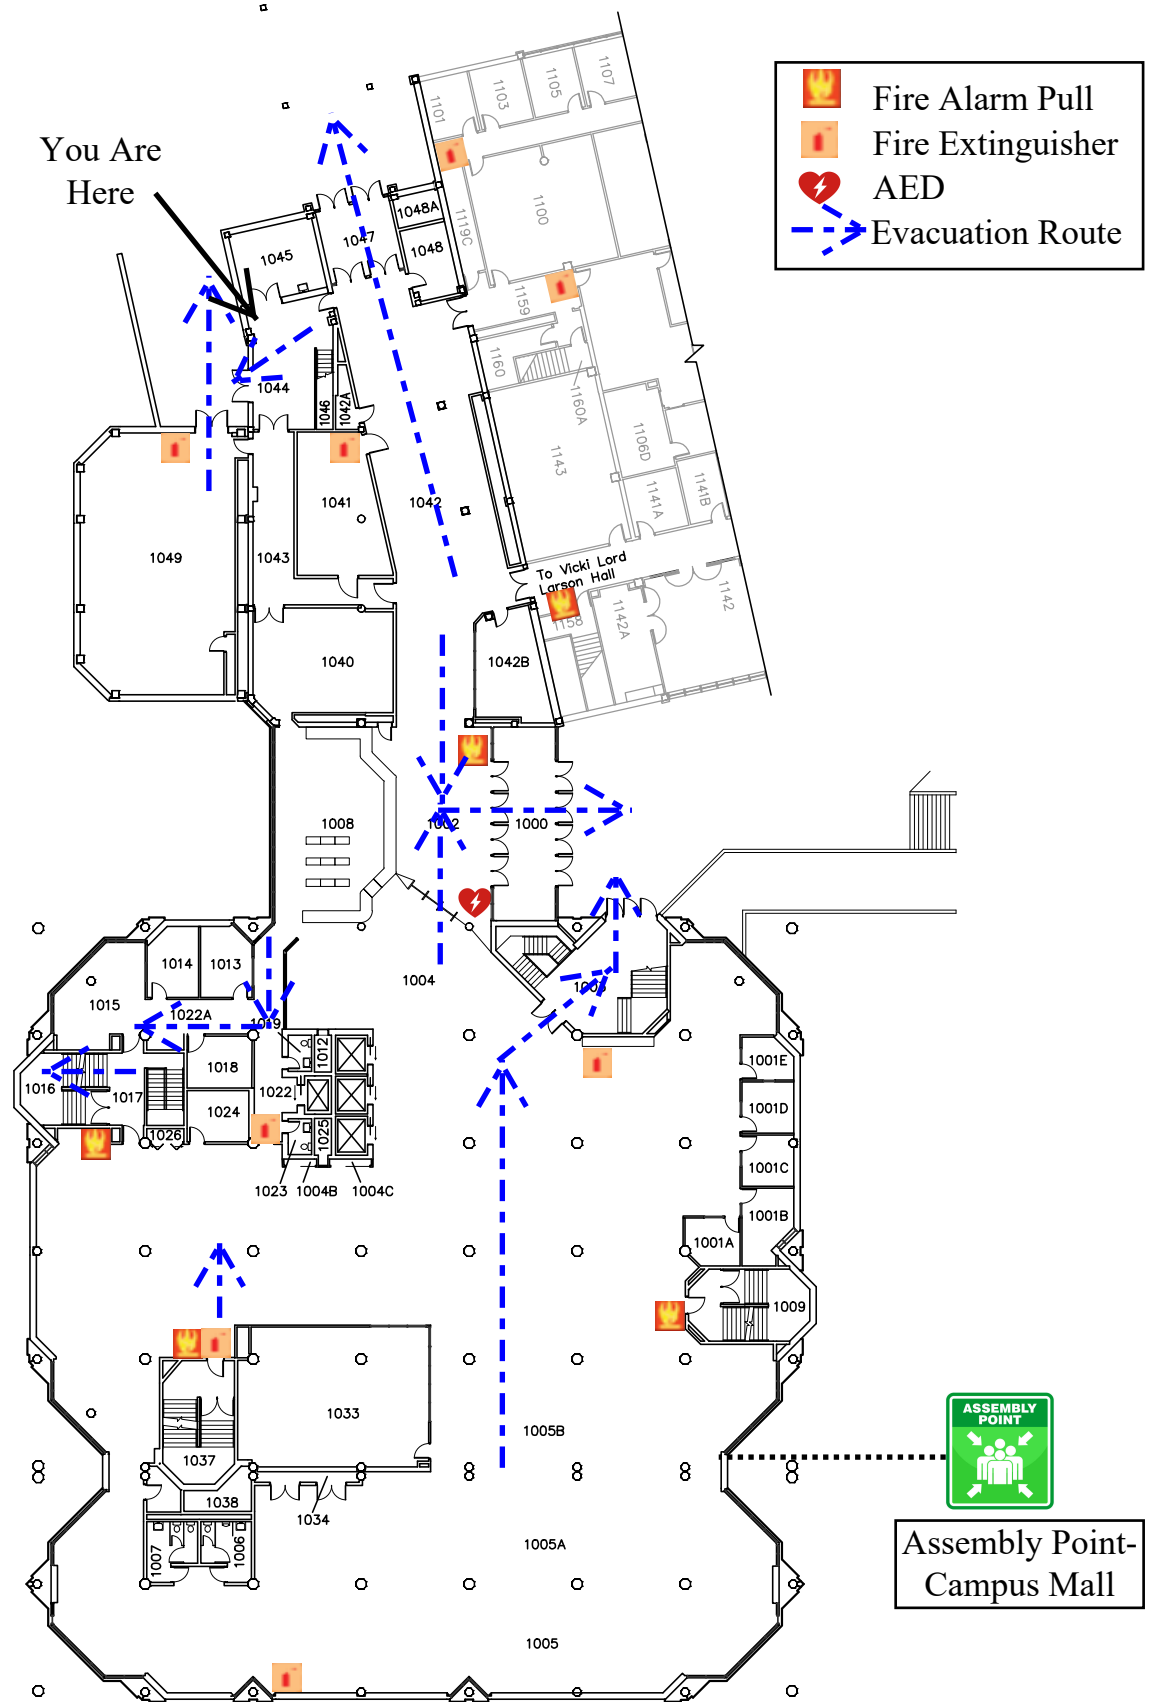

University of Wisconsin-Eau Claire

Facilities

McIntyre Library First Floor Plan


DATE:

Jan 2022

DWG NO:

9



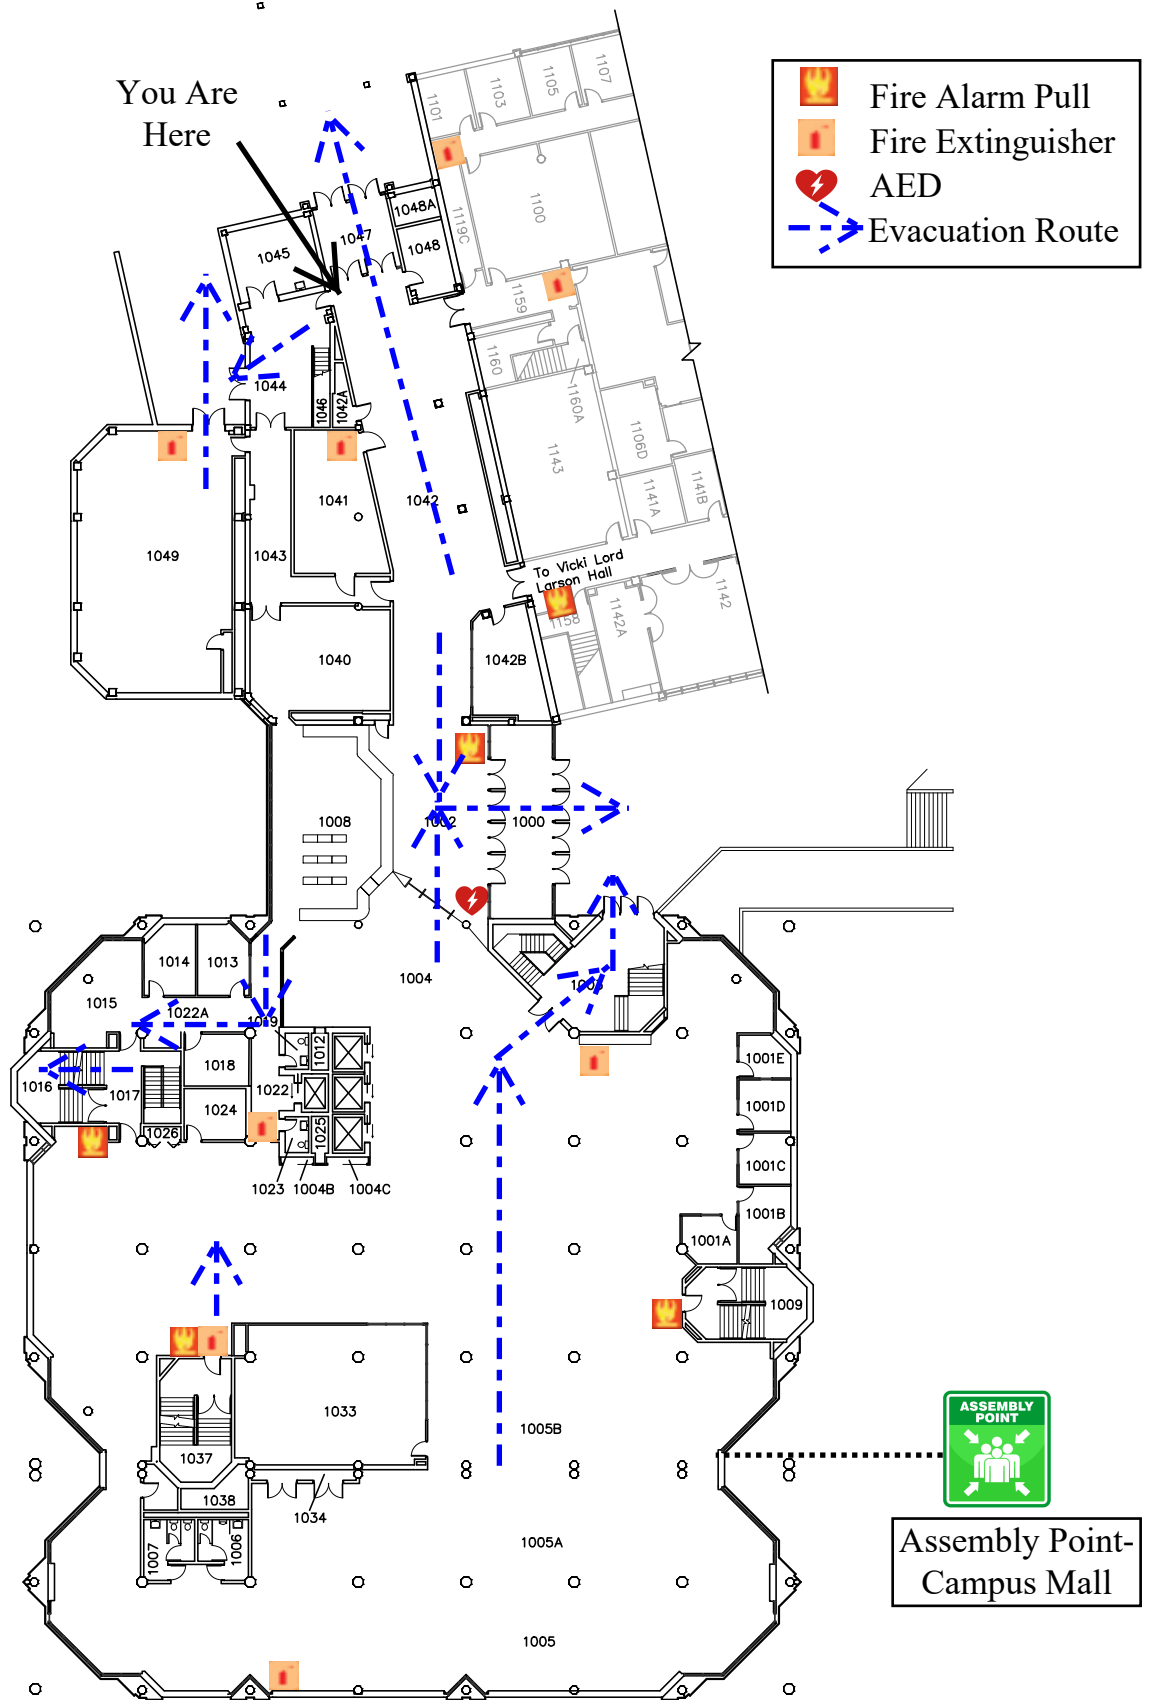

University of Wisconsin-Eau Claire

Facilities

McIntyre Library First Floor Plan


DATE:

Jan 2022

DWG NO:

10



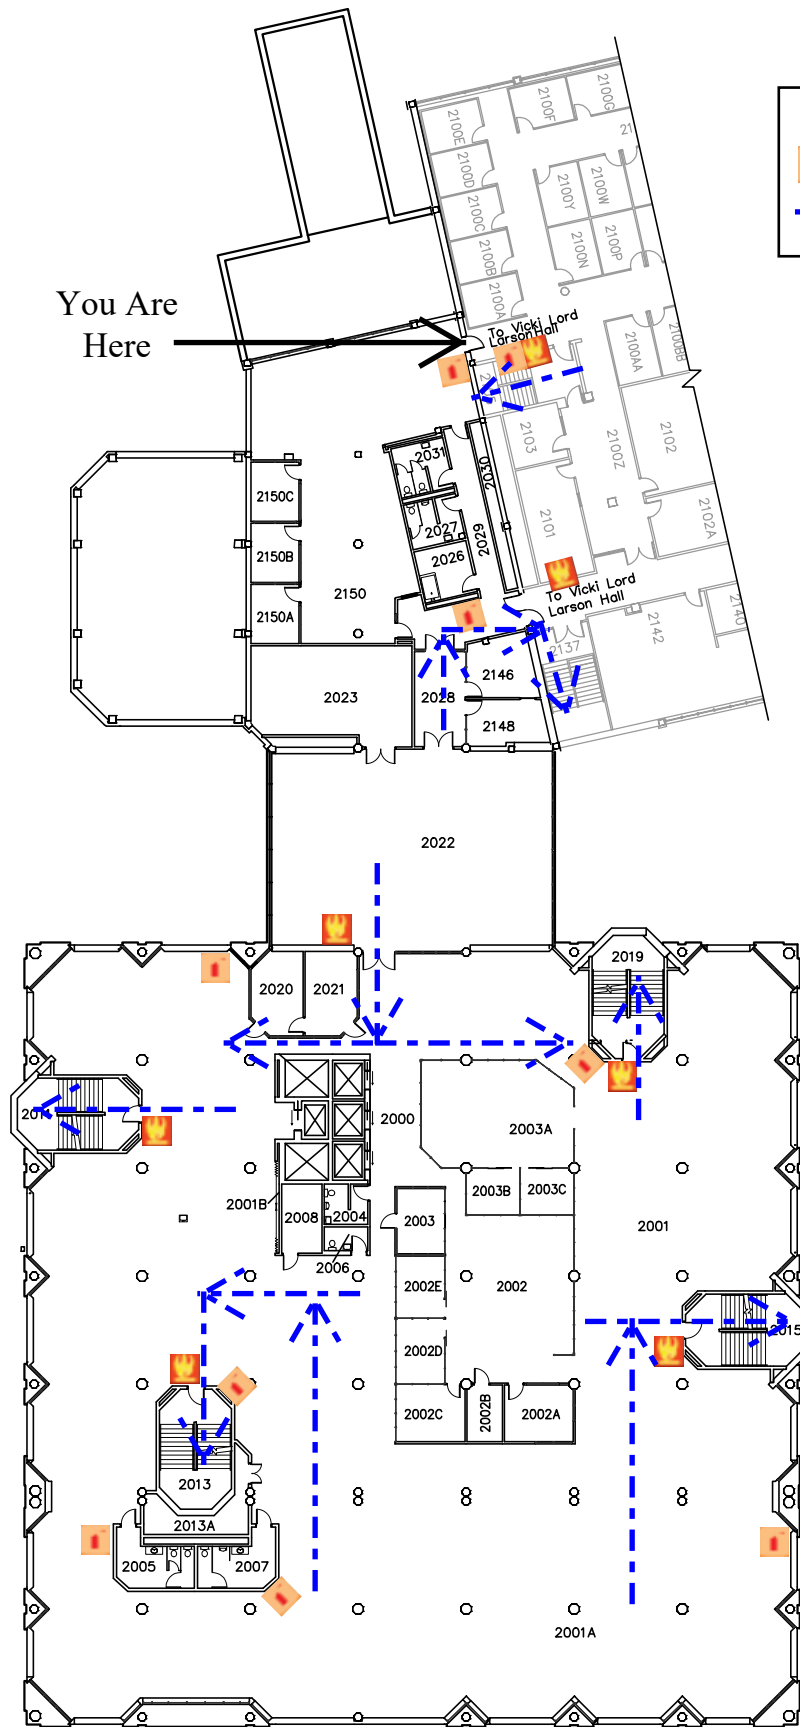


 Fire Alarm Pull
  Fire Extinguisher
  Evacuation Route


You Are Here




 Fire Alarm Pull
  Fire Extinguisher
  Evacuation Route

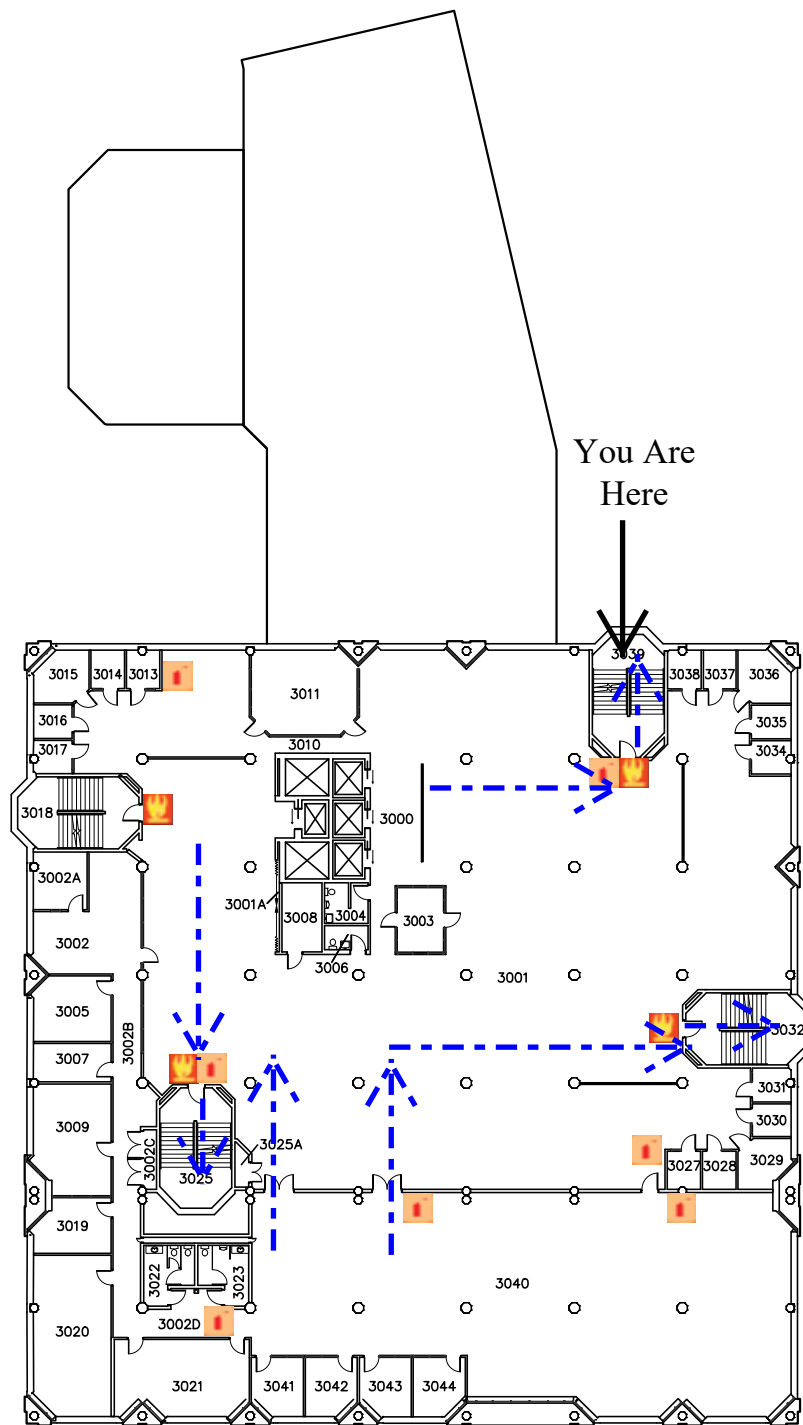


 Fire Alarm Pull
  Fire Extinguisher
  Evacuation Route

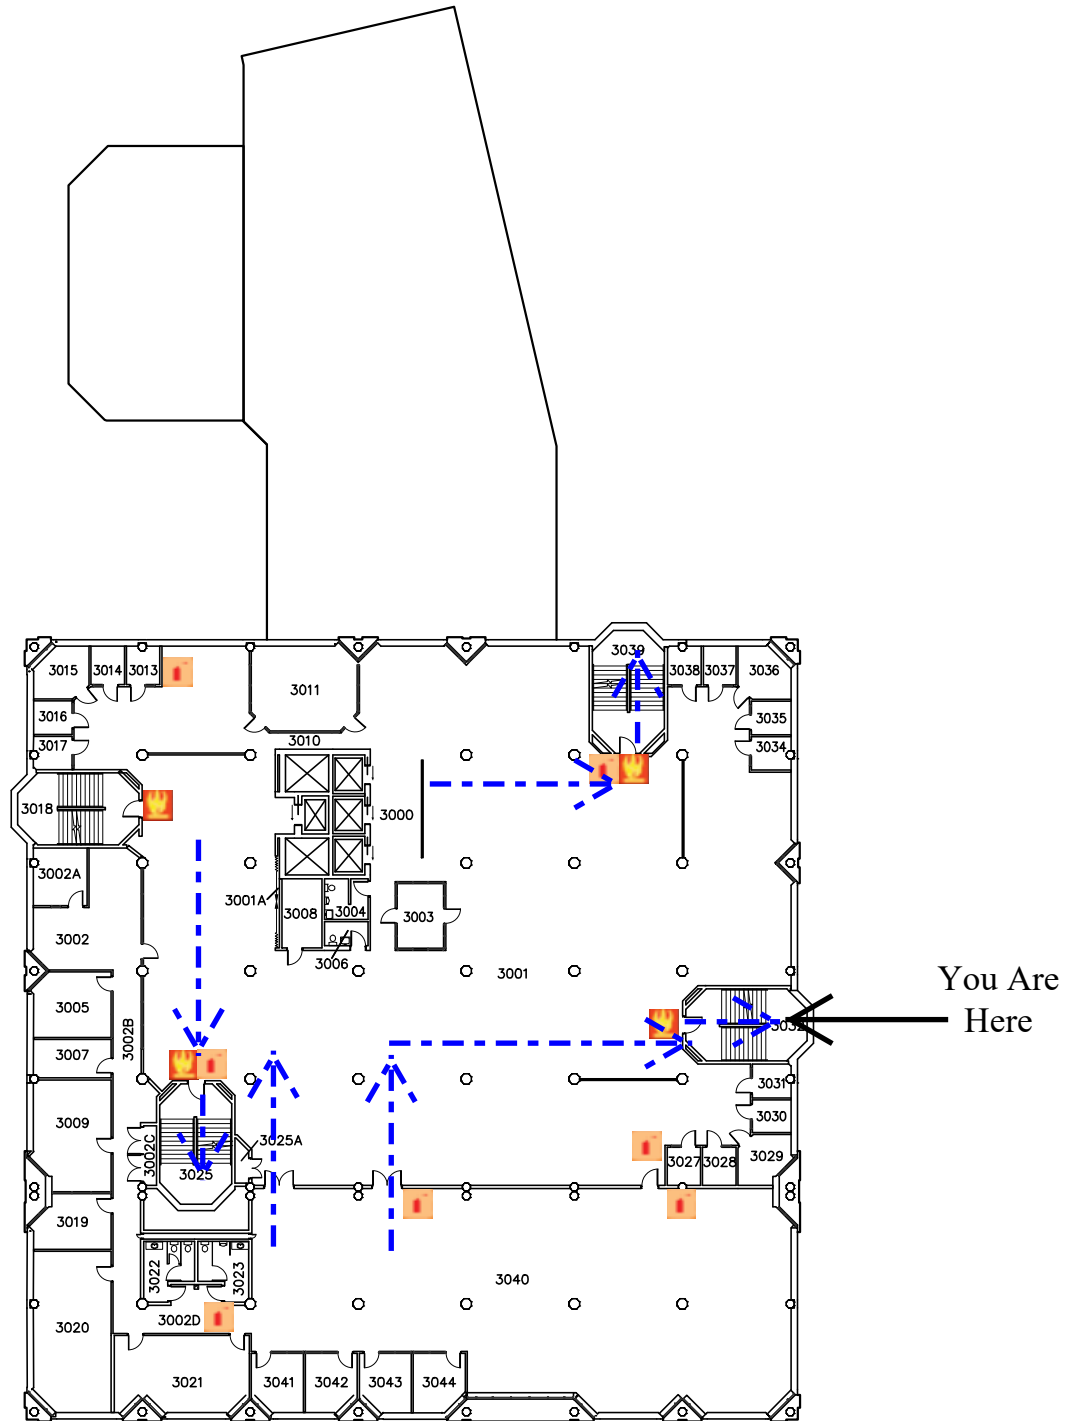


 Fire Alarm Pull
  Fire Extinguisher
  Evacuation Route

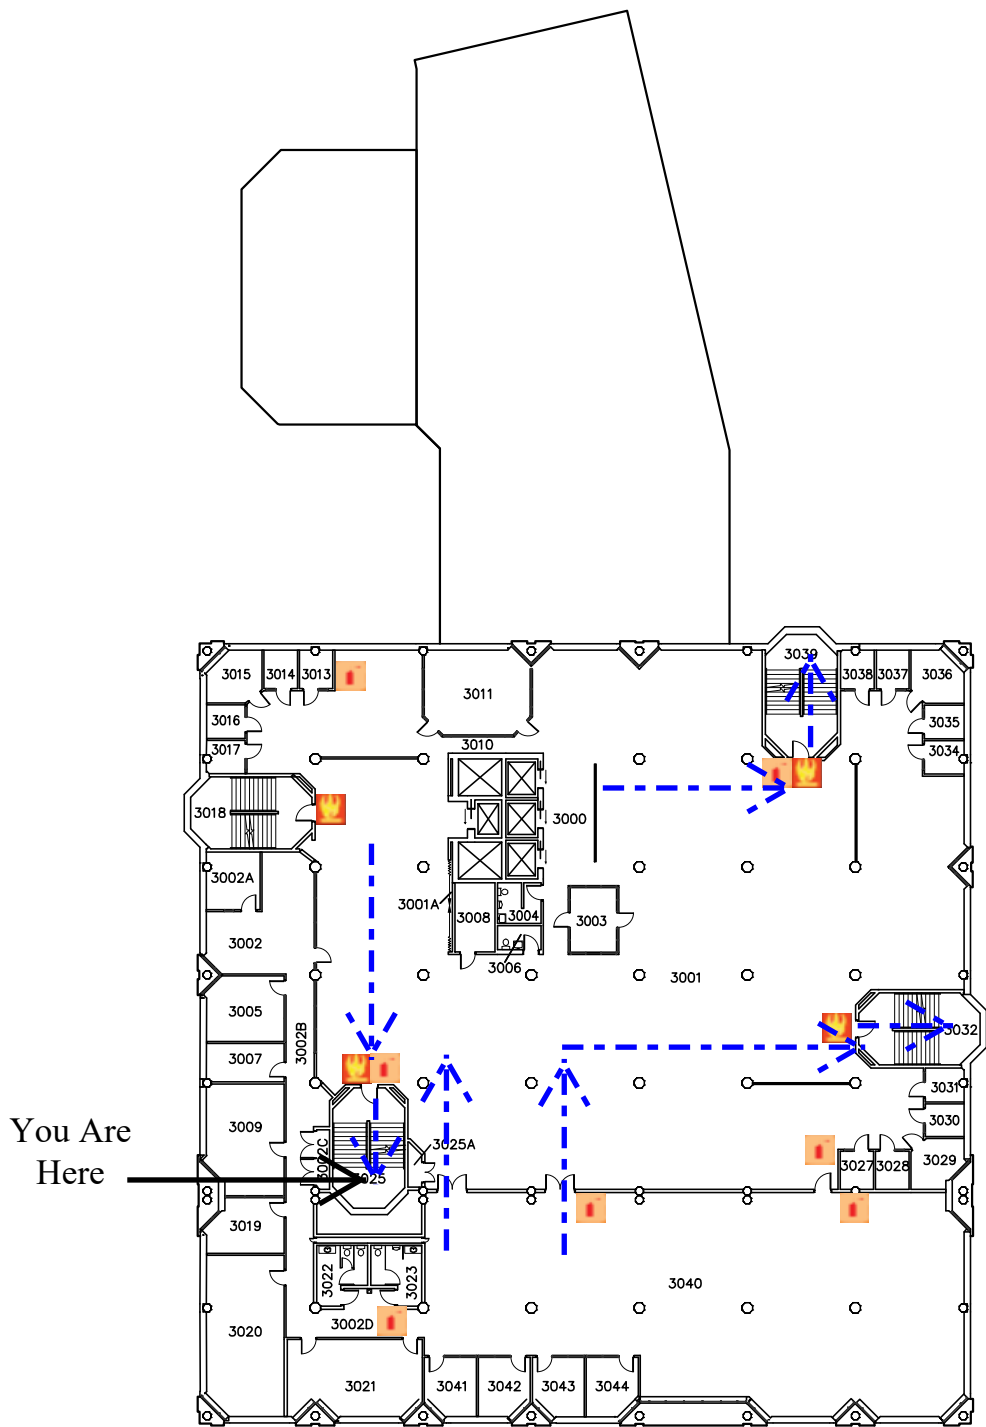


 Fire Alarm Pull
  Fire Extinguisher
  Evacuation Route

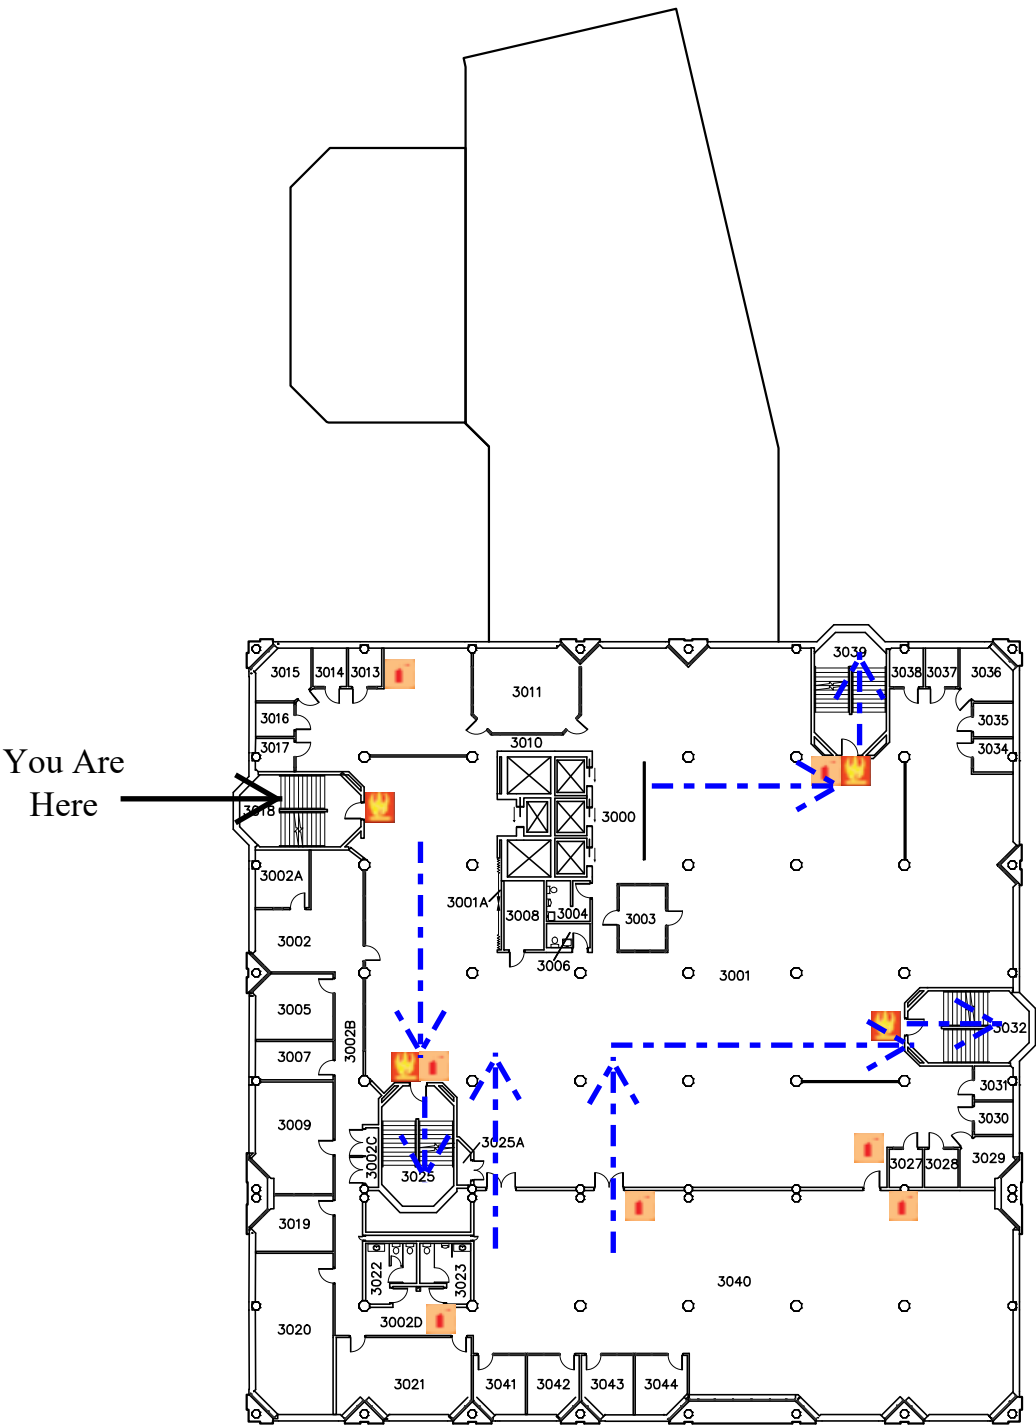


 Fire Alarm Pull
  Fire Extinguisher
  Evacuation Route

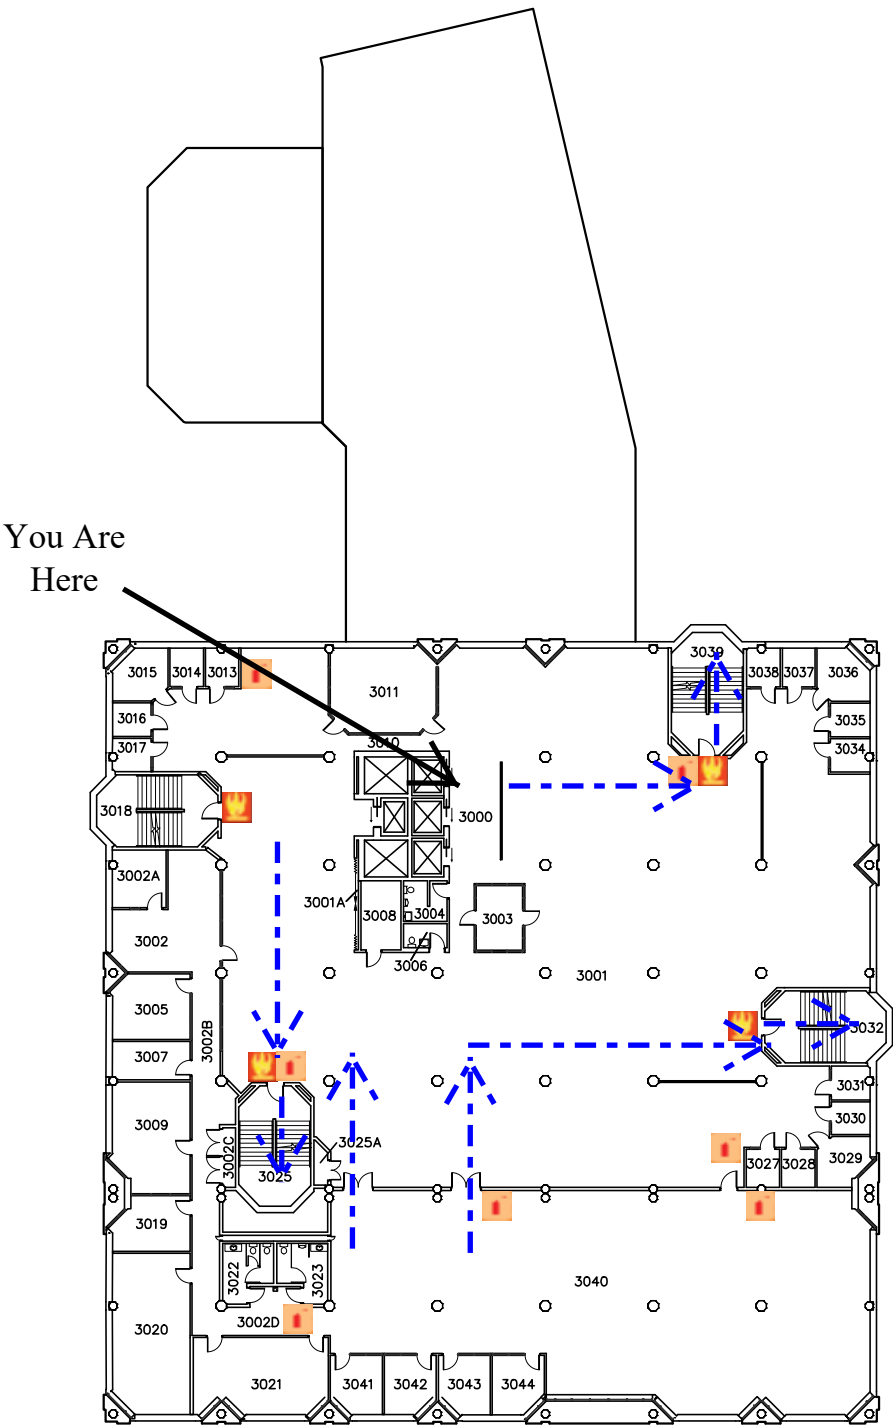


 Fire Alarm Pull
 Fire Extinguisher
 Evacuation Route

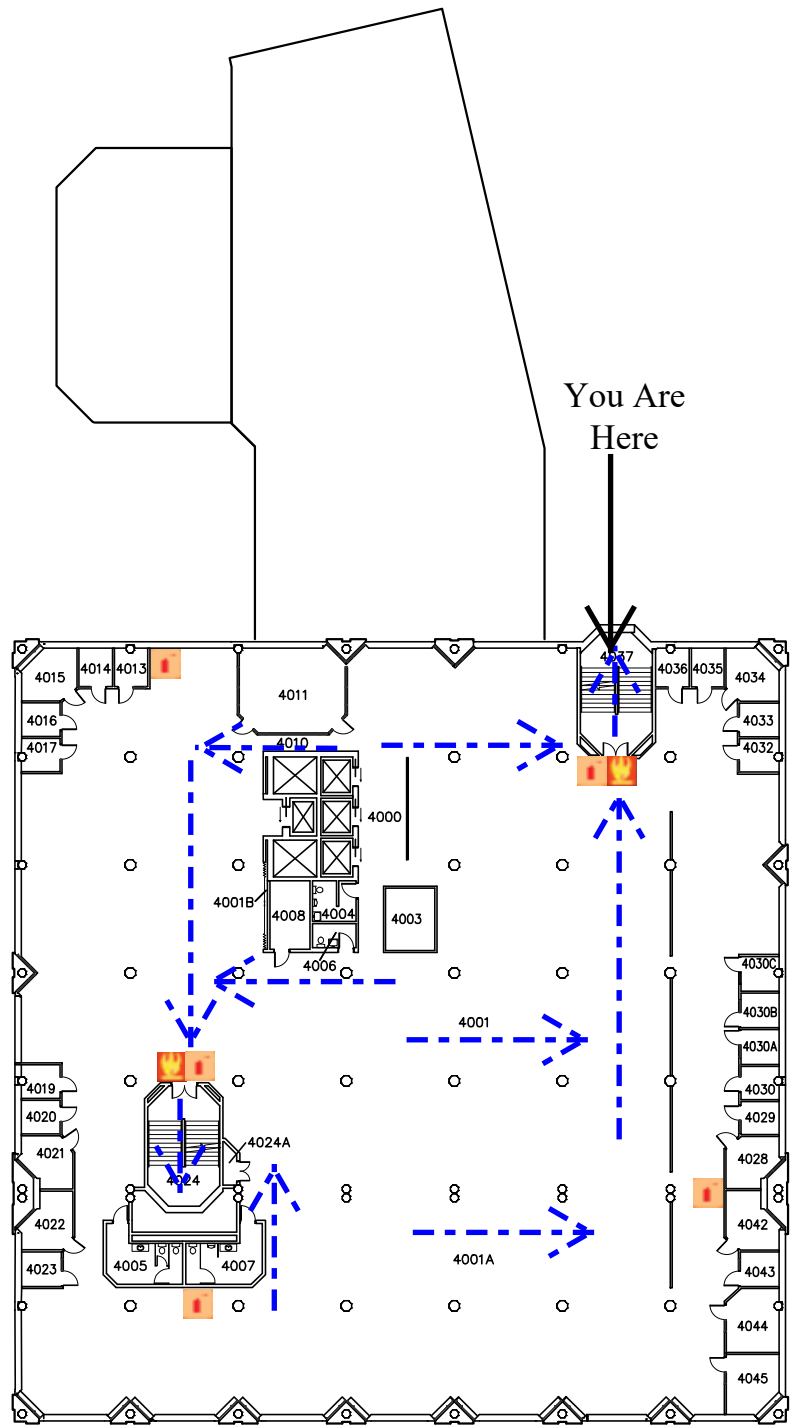


 Fire Alarm Pull
  Fire Extinguisher
  Evacuation Route

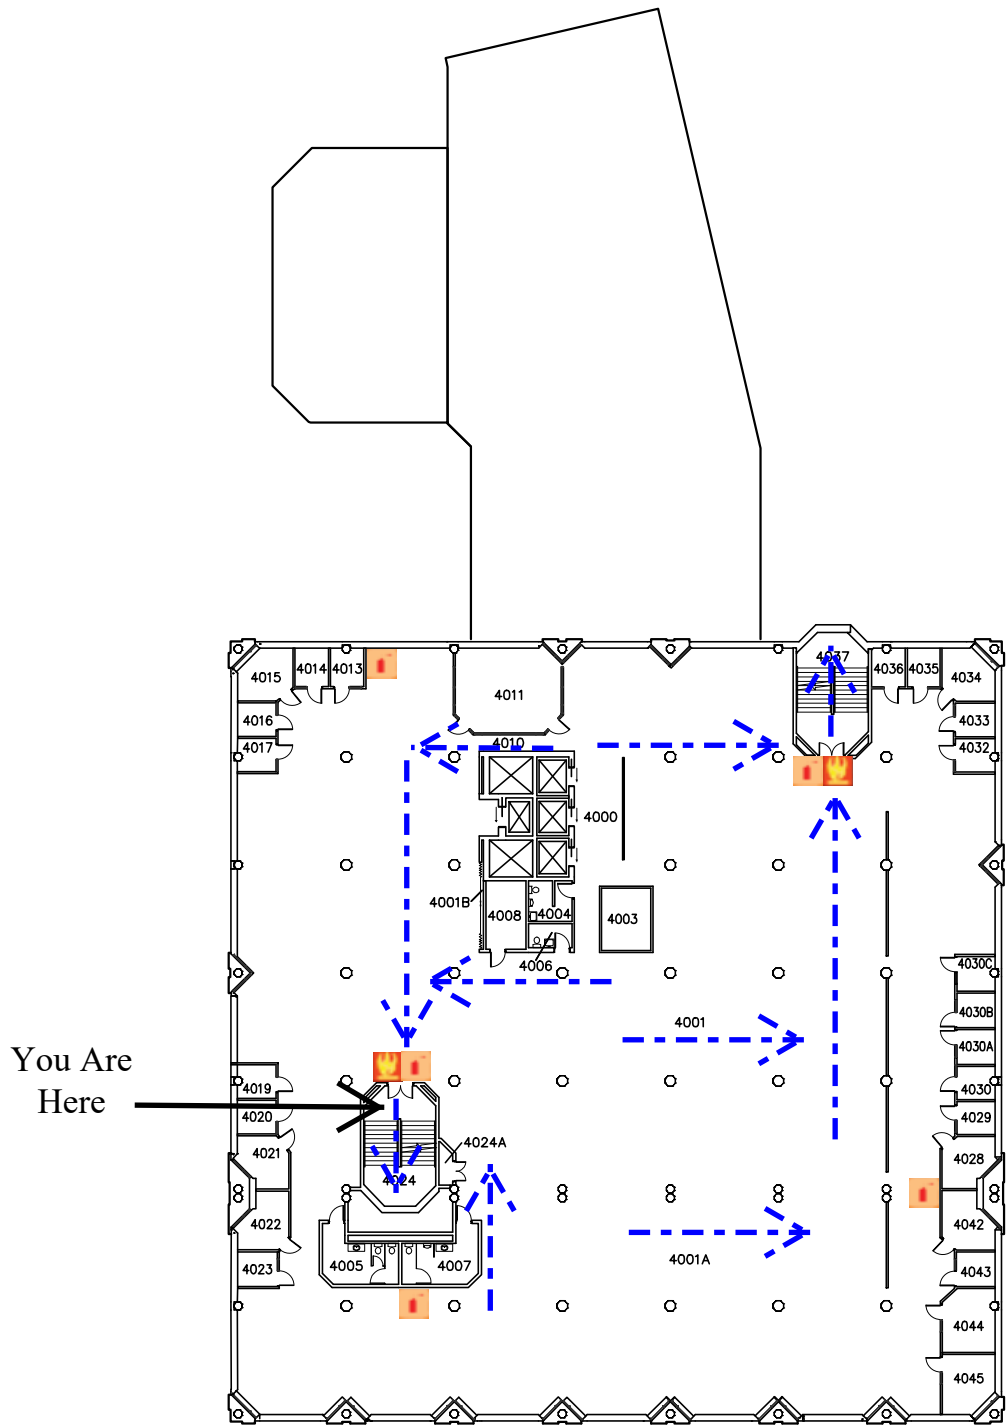


 Fire Alarm Pull
 Fire Extinguisher
 Evacuation Route

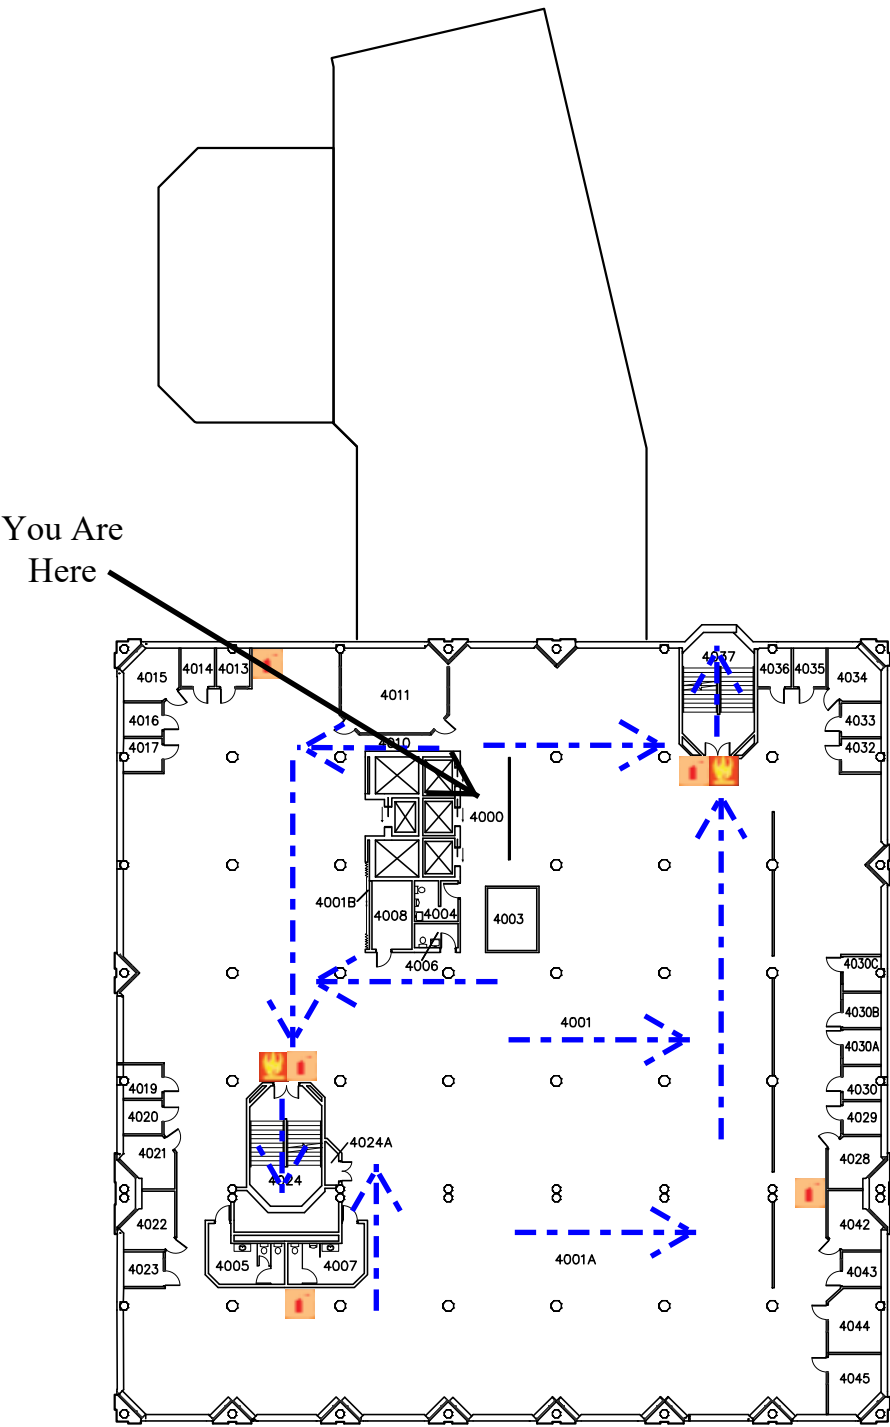


 Fire Alarm Pull
  Fire Extinguisher
  Evacuation Route

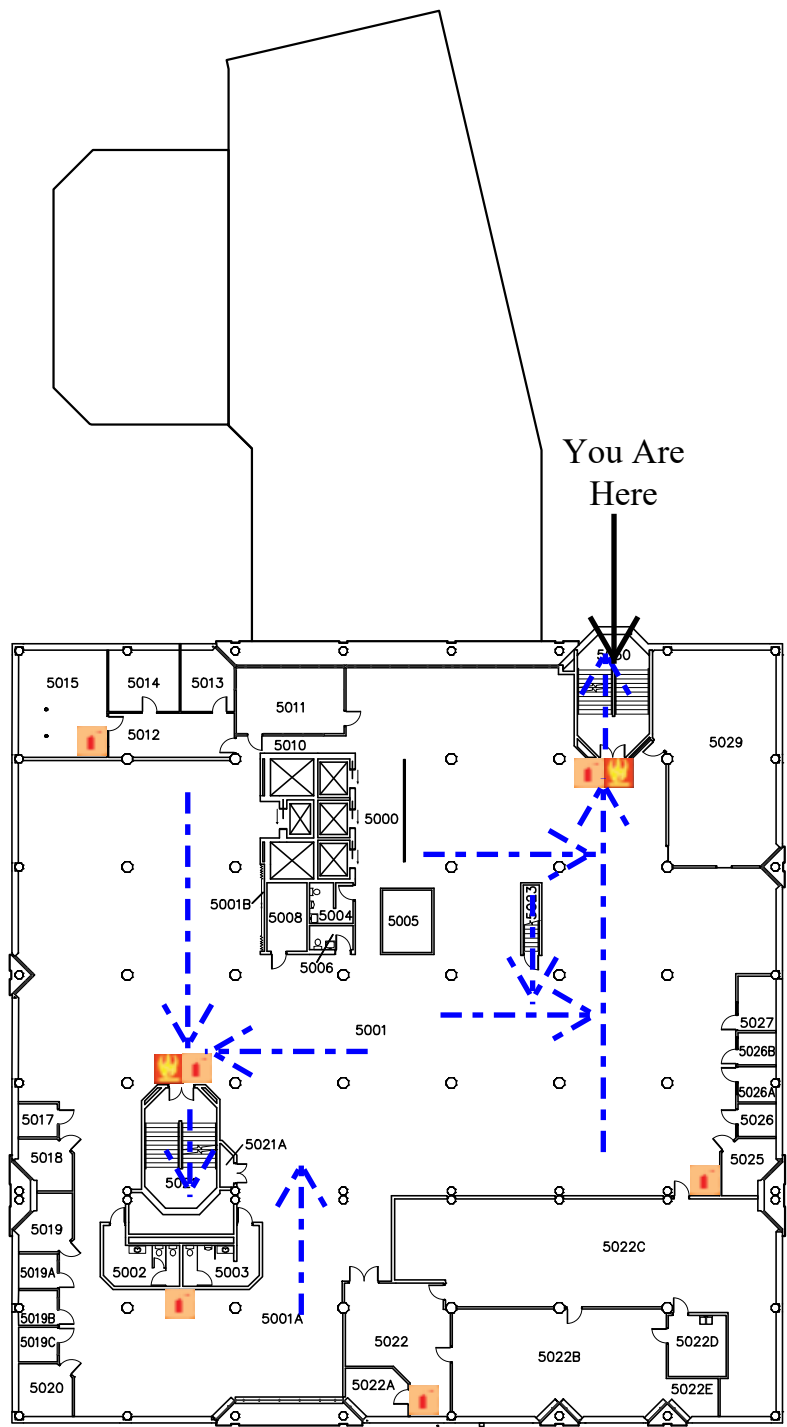

 Fire Alarm Pull
  Fire Extinguisher
  Evacuation Route

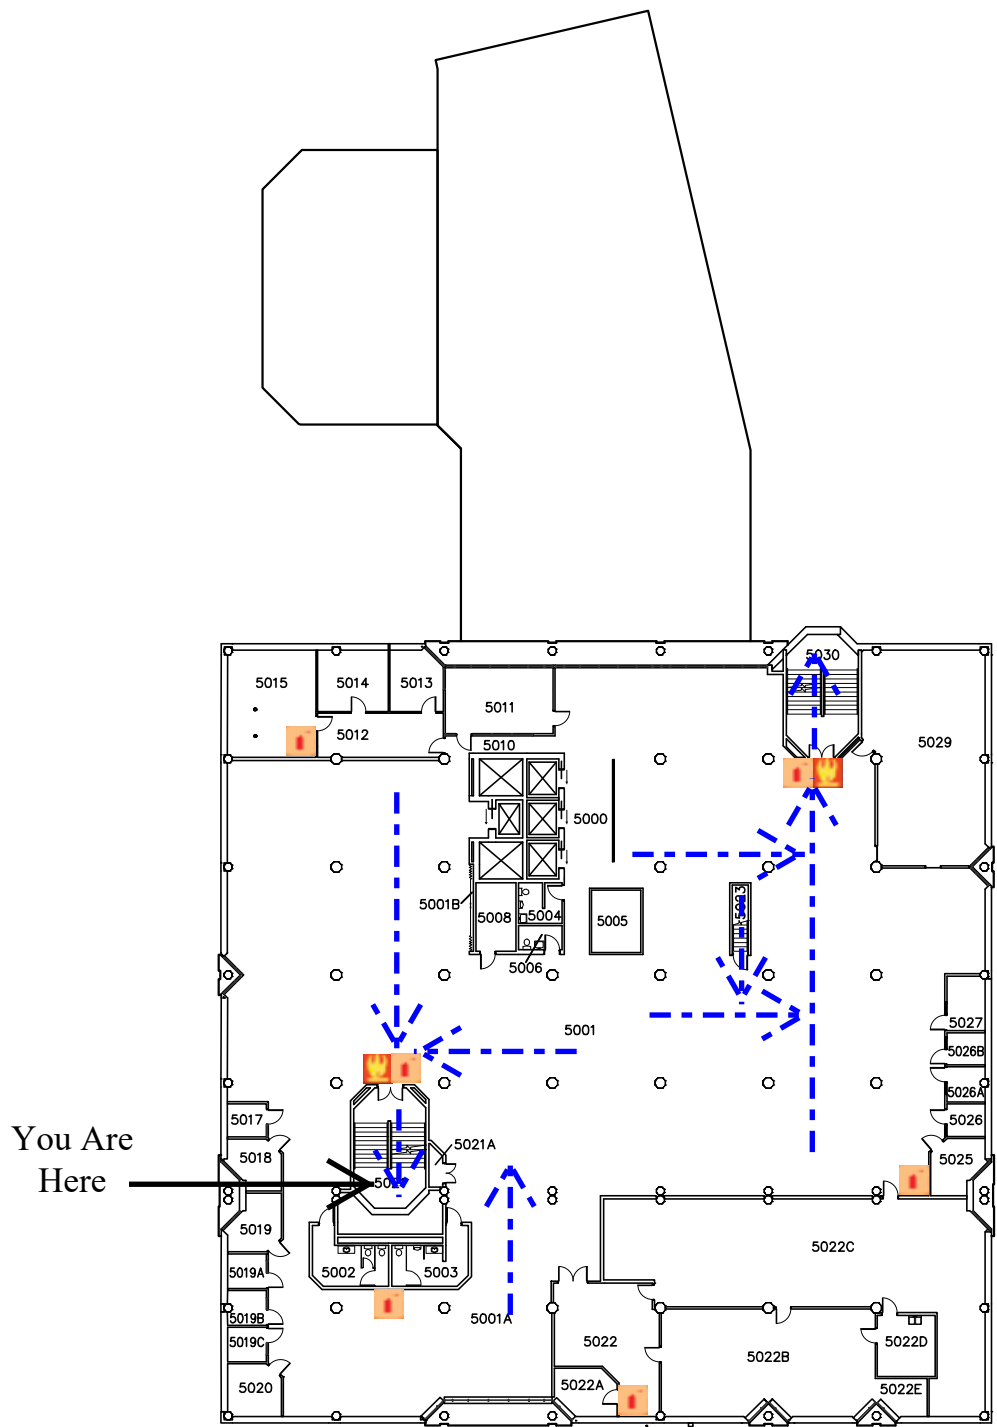

 Fire Alarm Pull
  Fire Extinguisher
  Evacuation Route

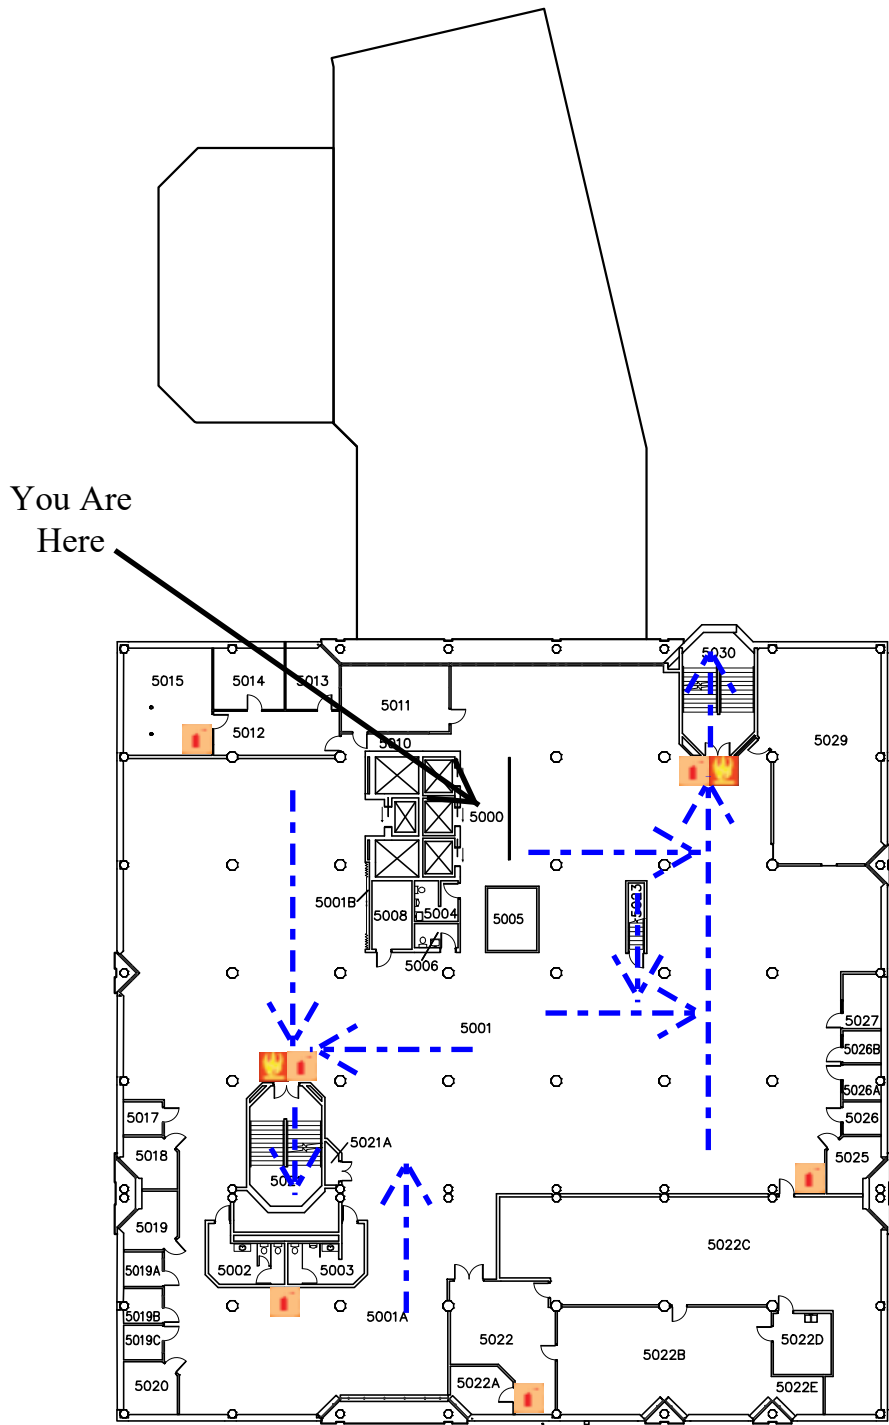

University of Wisconsin-Eau Claire
 Facilities

McIntyre Library
 Fifth Floor Plan

DATE:
 Jan 2022

DWG NO:
 3




Fire Alarm Pull


Fire Extinguisher


Evacuation Route

